



STATE OF NEW YORK
 OFFICE OF GENERAL SERVICES
 DESIGN AND CONSTRUCTION GROUP
 THE GOVERNOR NELSON A. ROCKEFELLER
 EMPIRE STATE PLAZA
 ALBANY, NY 12242



ADDENDUM NO. 2 TO PROJECT NO. 44509

**CONSTRUCTION WORK, PLUMBING WORK
 REHABILITATE E BLOCK BUILDING NO.2
 CLINTON CORRECTIONAL FACILITY
 ROUTE 374
 COOK STREET
 DANMORA, NEW YORK**

March 4, 2013

NOTE: This Addendum forms a part of the Contract Documents. Insert it in the Project Manual. Acknowledge receipt of this Addendum in the space provided on the Bid Form.

PLUMBING WORK

SPECIFICATIONS

1. SECTION 211200 - STANDPIPE AND HOSE SYSTEM; Add the following new Article 2.07:

"2.07 CABINETS

- A. Design hose cabinet to contain hose rack with 1-1/2 inch lined fire hose, hose valves of indicated sizes, and one 2-1/2 gallon fire extinguisher. The extinguisher will be NIC.
- B. Materials of Construction: Furniture steel, all joints welded and ground smooth, all corners and edges exposed to view rounded. Provide knockouts as required for the installation of fireline piping into the cabinet.
 1. Gage of Material (Minimum):

CABINETS	U.S.S. GAUGE
Surface Mounted	16 (0.062 inches)

2. Door: Institutional type, 20 gage (minimum) furniture steel, hollow metal construction, metal stiffeners, approximately 5/8 inch thick, and with a continuous hinge.
3. Door Latch: Cam action or snap action, solid metal handle.
- C. Paint: Factory finished interior in white baked on enamel; exterior prime coated.
- D. Identification: Pressure sensitive decal bearing the words "FIRE HOSE". Letters shall be at least 3 inches high set on a contrasting background."


DRAWINGS

1. Drawing P-402 - Partial Floor Plans - Plumbing
 - A. Revise Drawing Note 5 to read as follows:

"5. Provide 1-1/2 in. fire hose valve, 100 ft. of fire hose and nozzle in existing cabinet."
 - B. Add Drawing SKP-402B dated, 3/4/2013 indicating the fire department connection and related piping.
 - C. Add Drawing SKP-402C dated, 3/4/2013 indicating the fire department connection and related piping.
 - D. Add Drawing SKP-402D dated, 3/4/2013 indicating the fire department connection and related piping.

END OF ADDENDUM

James Dirolf, P.E.
Director of Design

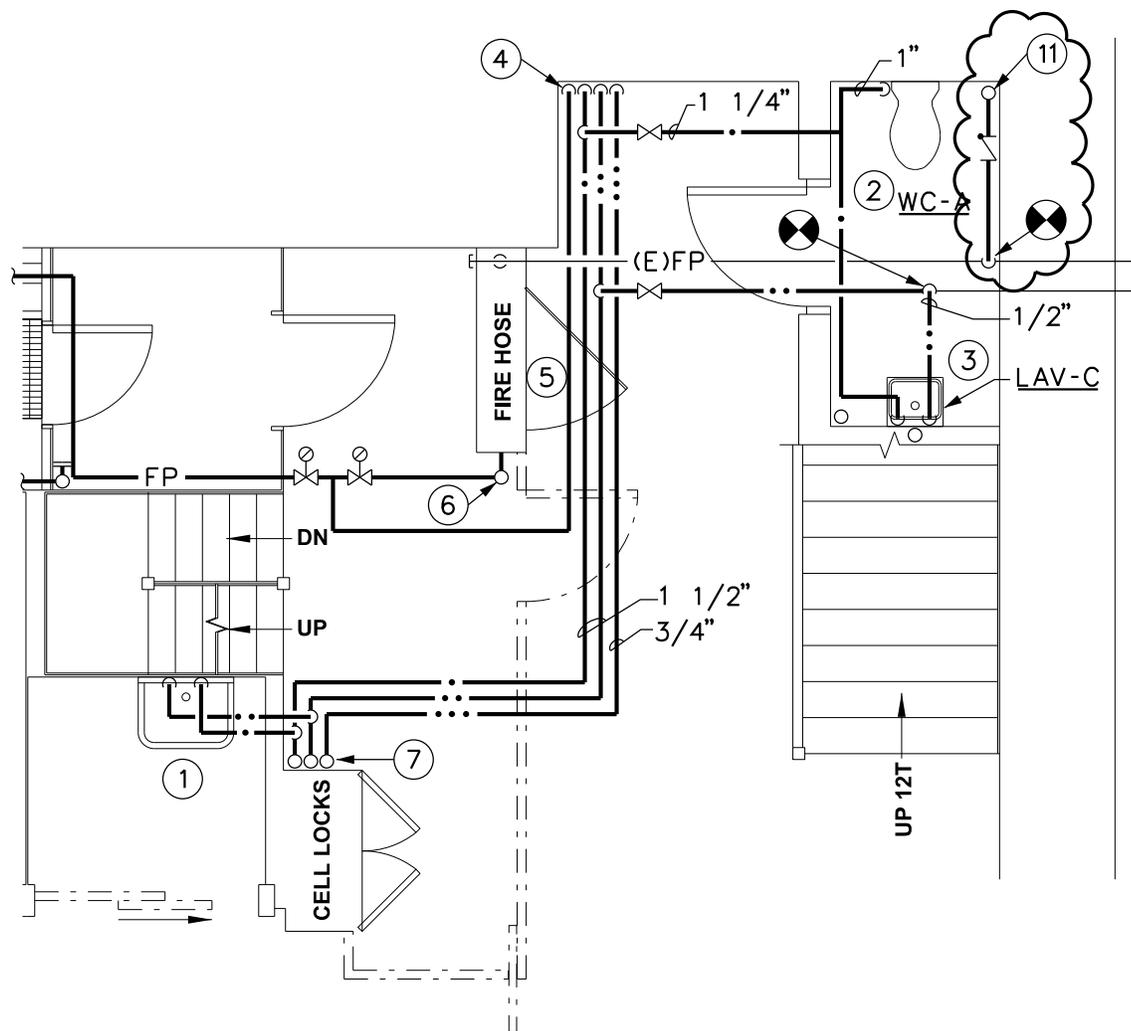

DRAWING NOTES:

(11) 4" FROM FIRE DEPARTMENT CONNECTION

**PARTIAL FIRST FLOOR PLAN
PLUMBING**

SCALE: 1/4" = 1'-0"



NYS OFFICE OF GENERAL SERVICES

Serving New York

CONTRACT: PLUMBING
 PROJ. NO: 44509-P
 DATE: 3/4/13
 DRAWN: SJZ
 APPROVED: DMS



ENGINEERING P.C.

MECHANICAL/ELECTRICAL
 ENGINEERING CONSULTANTS
 WATERFRONT VILLAGE CENTER
 SUITE 320, 60 LAKEFRONT BOULEVARD
 BUFFALO, NY 14202
 (716)845-3022 FAX: (716)845-8187
 M/E JOB 12063


ADDENDUM #2 REFERENCE DRAWING: P-402

SHEET TITLE:
 PARTIAL FIRST FLOOR PLAN
 PLUMBING

PROJECT:
 REHABILITATE 'E' BLOCK
 BUILDING No.2

WARNING: THE ALTERATION OF THIS MATERIAL IN ANY WAY, UNLESS
 DONE UNDER THE DIRECTION OF A COMPARABLE PROFESSIONAL, I.E.
 ARCHITECT FOR AN ARCHITECT, ENGINEER FOR AN ENGINEER OR LANDSCAPE
 ARCHITECT FOR A LANDSCAPE ARCHITECT, IS A VIOLATION OF THE NEW YORK
 STATE EDUCATION LAW AND/OR REGULATIONS AND IS A CLASS 'A'
 MISDEMEANOR.


DWG NO:
 SKP-402B

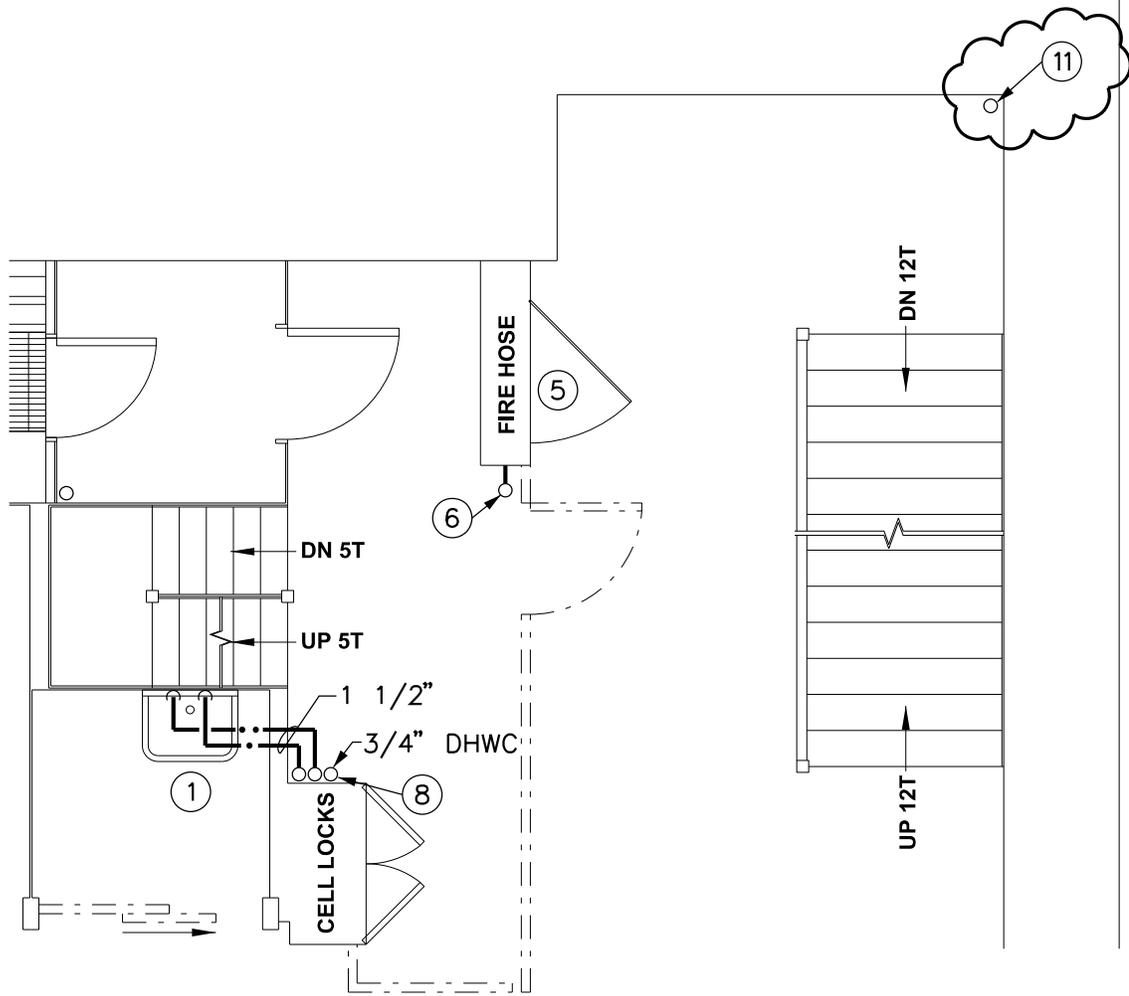

DRAWING NOTES:
 (11) 4" FROM FIRE DEPARTMENT CONNECTION

PARTIAL SECOND FLOOR PLAN PLUMBING


SCALE: 1/4" = 1'-0"

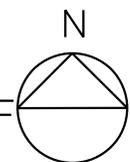

CONTRACT: PLUMBING
 PROJ. NO: 44509-P
 DATE: 3/4/13
 DRAWN: SJZ
 APPROVED: DMS



ADDENDUM #2	REFERENCE DRAWING: P-402
SHEET TITLE:	PARTIAL FIRST FLOOR PLAN PLUMBING
PROJECT:	REHABILITATE 'E' BLOCK BUILDING No.2
WARNING: THE ALTERATION OF THIS MATERIAL IN ANY WAY, UNLESS DONE UNDER THE DIRECTION OF A COMPARABLE PROFESSIONAL, I.E. ARCHITECT FOR AN ARCHITECT, ENGINEER FOR AN ENGINEER OR LANDSCAPE ARCHITECT FOR A LANDSCAPE ARCHITECT, IS A VIOLATION OF THE NEW YORK STATE EDUCATION LAW AND/OR REGULATIONS AND IS A CLASS 'A' MISDEMEANOR.	DWG NO: SKP-402C

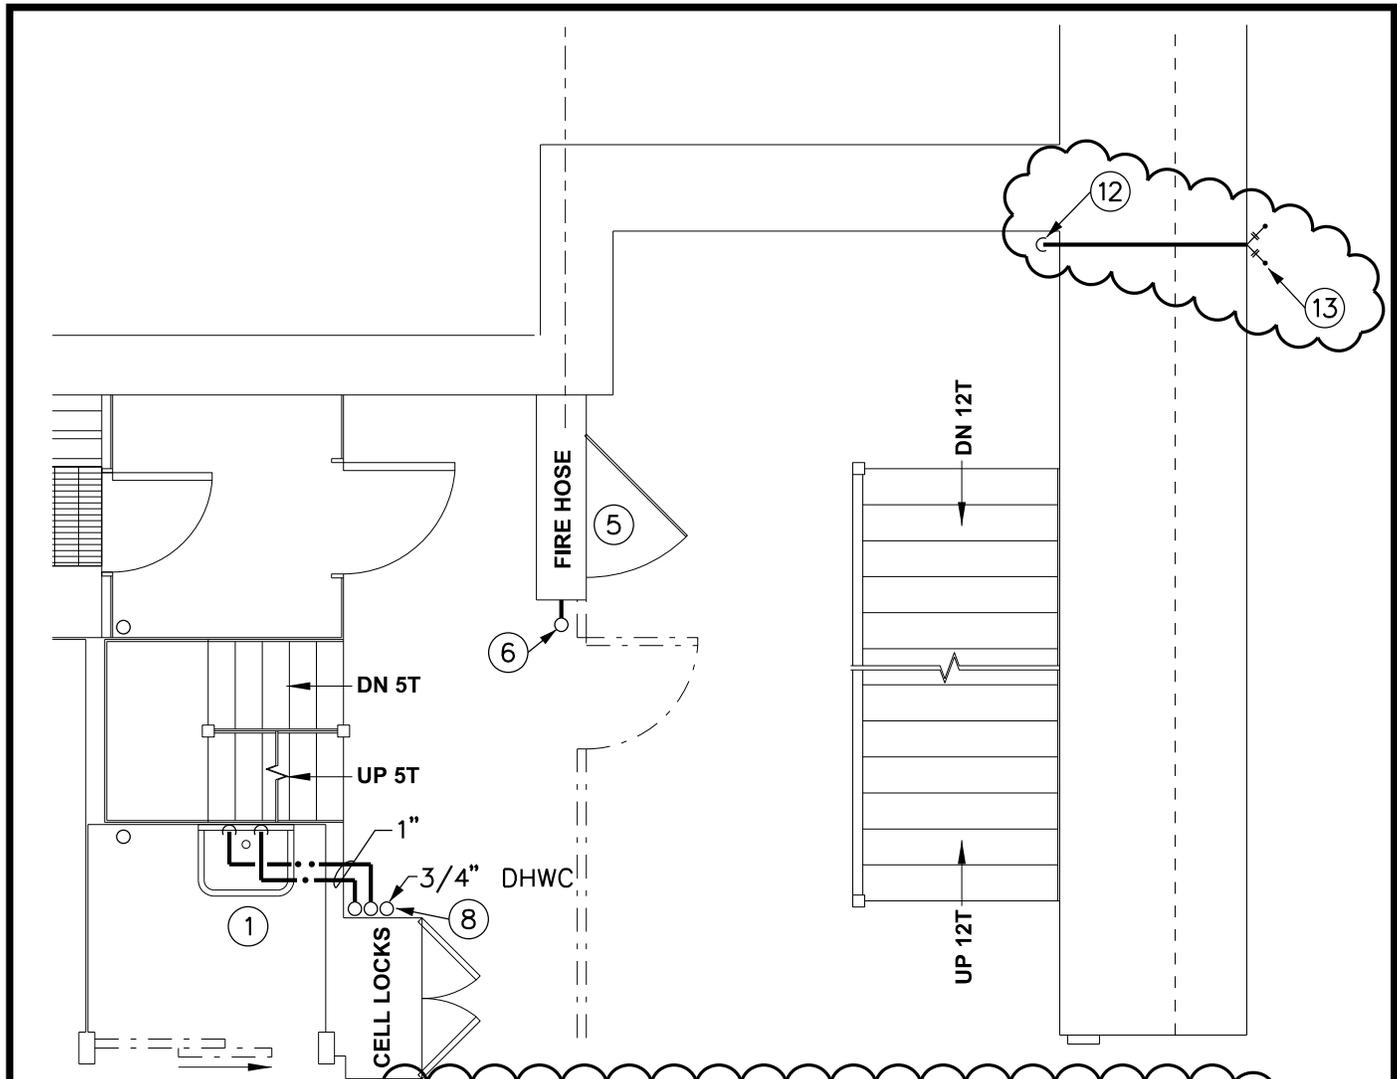

DRAWING NOTES:


(12) 4" FROM FIRE DEPARTMENT CONNECTION DN.

(13) 4" X 2 1/2" X 2 1/2" FIRE DEPARTMENT CONNECTION

PARTIAL THIRD FLOOR PLAN

PLUMBING

SCALE: 1/4" = 1'-0"

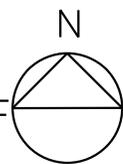

CONTRACT: PLUMBING
 PROJ. NO: 44509-P
 DATE: 3/4/13
 DRAWN: SJZ
 APPROVED: DMS



ADDENDUM #2	REFERENCE DRAWING: P-402
SHEET TITLE:	PARTIAL FIRST FLOOR PLAN PLUMBING
PROJECT:	REHABILITATE 'E' BLOCK BUILDING No.2
WARNING: THE ALTERATION OF THIS MATERIAL IN ANY WAY, UNLESS DONE UNDER THE DIRECTION OF A COMPARABLE PROFESSIONAL, I.E. ARCHITECT FOR AN ARCHITECT, ENGINEER FOR AN ENGINEER OR LANDSCAPE ARCHITECT FOR A LANDSCAPE ARCHITECT, IS A VIOLATION OF THE NEW YORK STATE EDUCATION LAW AND/OR REGULATIONS AND IS A CLASS 'A' MISDEMEANOR.	DWG NO: SKP-402D