



STATE OF NEW YORK  
OFFICE OF GENERAL SERVICES  
DESIGN AND CONSTRUCTION GROUP  
THE GOVERNOR NELSON A. ROCKEFELLER  
EMPIRE STATE PLAZA  
ALBANY, NY 12242



---

---

**ADDENDUM NO. 1 TO PROJECT NO. 44532**

**CONSTRUCTION WORK, PLUMBING WORK, HVAC WORK and ELECTRIC WORK  
REHABILITATE SHOWERS, BLOCKS A, B, C, D, E, F, G & H  
GREEN HAVEN CORRECTIONAL FACILITY  
ROUTE 216  
STORMVILLE, NY**

January 9, 2015

**NOTE:** This Addendum forms a part of the Contract Documents. Insert it in the Project Manual. Acknowledge receipt of this Addendum in the space provided on the Bid Form.

**PLUMBING DRAWINGS**


1. Drawing No. P-103 Detail 1: Change note "Second Floor C-Block Shower Plumbing Plan Similar, Refer to Detail 2 of P-103 for Non-ADA Shower Configuration and Piping" to "Refer to Details 2 for Second Floor and Detail 4 for Third Floor Of C-Block on Drawing P-101 for Typical Non-ADA Shower Configuration and Piping".
2. Drawing No. P-002 Add the Following as a General Note:  
"Location Plans this Drawing Depict 2 shower areas per floor in each of Cell Blocks A, B, C, D, E, F, G and H. There are a total of 48 Shower Areas. Each Shower Area has 2 shower cabinets SH-1 per the typical details shown on drawing P-101 except for C Block first floor which has one shower cabinet SH-2 per Shower Area. There are a total of 94 Shower Cabinets required (92 type SH-1 and 2 type SH-2)".
3. Drawing No. P-001 Detail 1: Delete Detail and Replace with Detail 1/P-SK1 shown on attached Drawing No. P-SK1 dated 1/7/15.
4. Drawing No. P-001: Add Detail 1/P-SK-2 shown on attached Drawing No. P-SK2 dated 1/7/15.

**ELECTRICAL DRAWINGS**

5. Drawing No. E-101 Detail 6: Change note "EF-1 (EF-2 FOR CELL BLOCK C AND EF- 3 FOR CELL BLOCK D)" to "EF-1 FOR CELL BLOCKS A, B, E, F, G & H (EF-2 FOR CELL BLOCK C AND EF-3 FOR CELL BLOCK D

Margaret F. Larkin  
Executive Director

**END OF ADDENDUM**

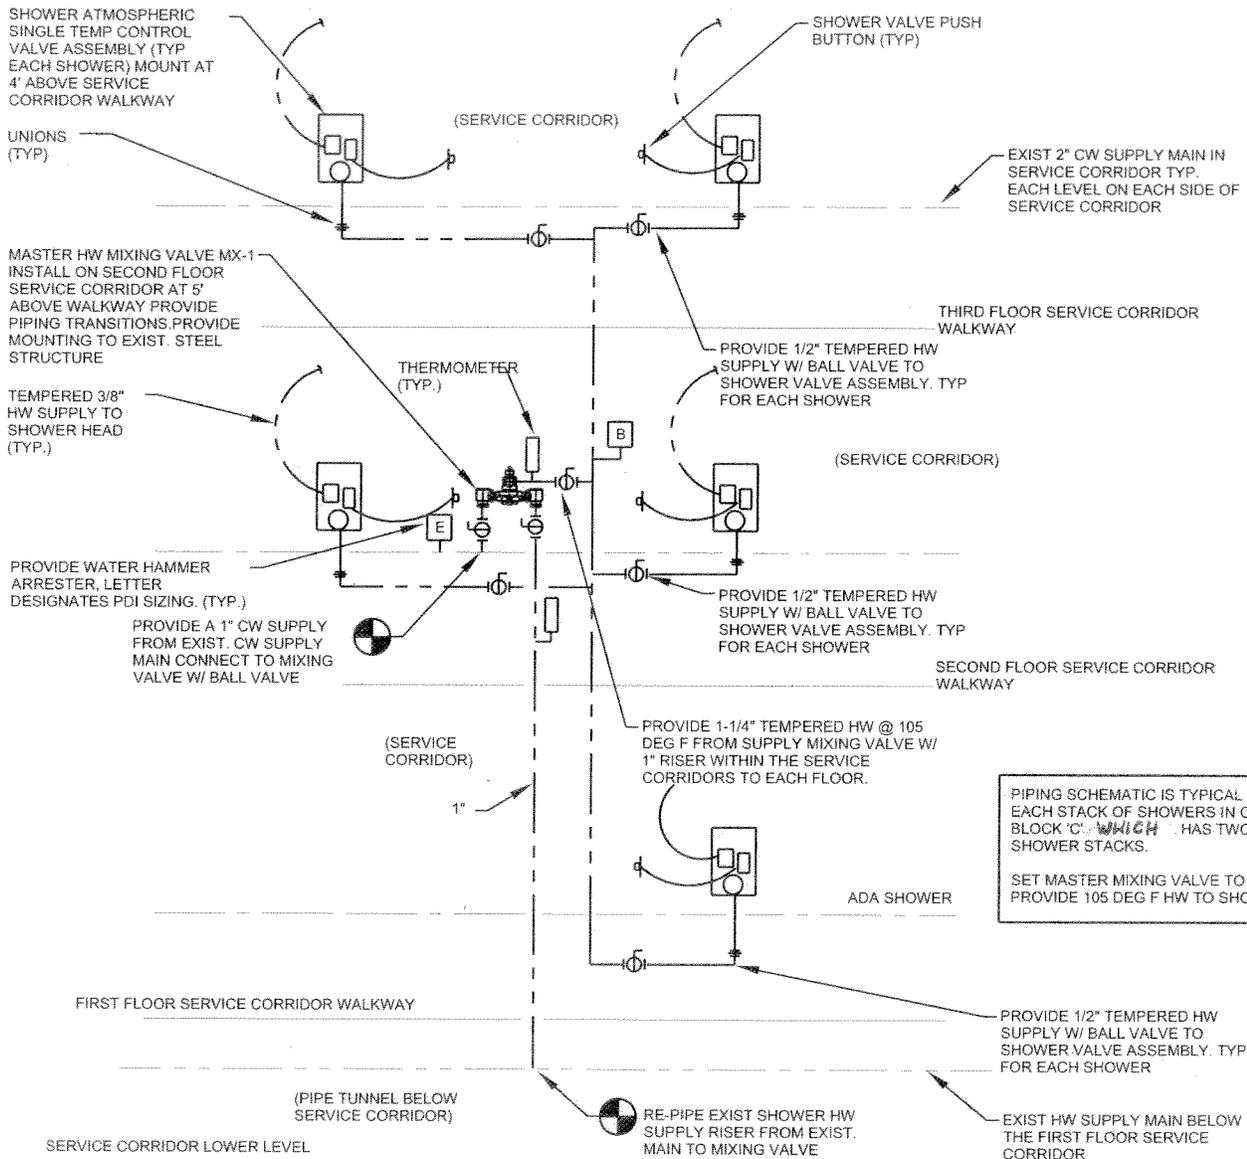

# 1 SHOWER PIPING SCHEMATIC - C BLOCK

P-SK1 SCALE: N.T.S.

REFERENCE DRAWING: P-001



860 Hooper Road  
Endwell, New York 13760  
Tel: 607.231.6600  
Fax: 607.231.6651

Email: mail@deltaengineers.com  
Web: www.deltaengineers.com

DELTA PROJECT NUMBER: 2010.589.022


SHEET TITLE:  
ADDENDUM #1  
SHOWER PIPING SCHEMATIC

PROJECT: REHABILITATE SHOWERS  
BLOCKS A, B, C, D, E, F, G, & H  
GREEN HAVEN CORRECTIONAL FACILITY

THE ALTERATION OF THIS MATERIAL IN ANY WAY, UNLESS DONE UNDER THE DIRECTION OF A COMPARABLE PROFESSIONAL, I.E. ARCHITECT FOR AN ARCHITECT, ENGINEER FOR AN ENGINEER OR LANDSCAPE ARCHITECT FOR A LANDSCAPE ARCHITECT, IS A VIOLATION OF THE NEW YORK STATE EDUCATION LAW AND/OR REGULATIONS AND IS A CLASS 'A' MISDEMEANOR.

DWG NO:  
P-SK1

CONTRACT: PLUMBING  
PROJ. NO: 44532  
DATE: 01-07-2015  
DRAWN: KLB  
APPROVED: TAC

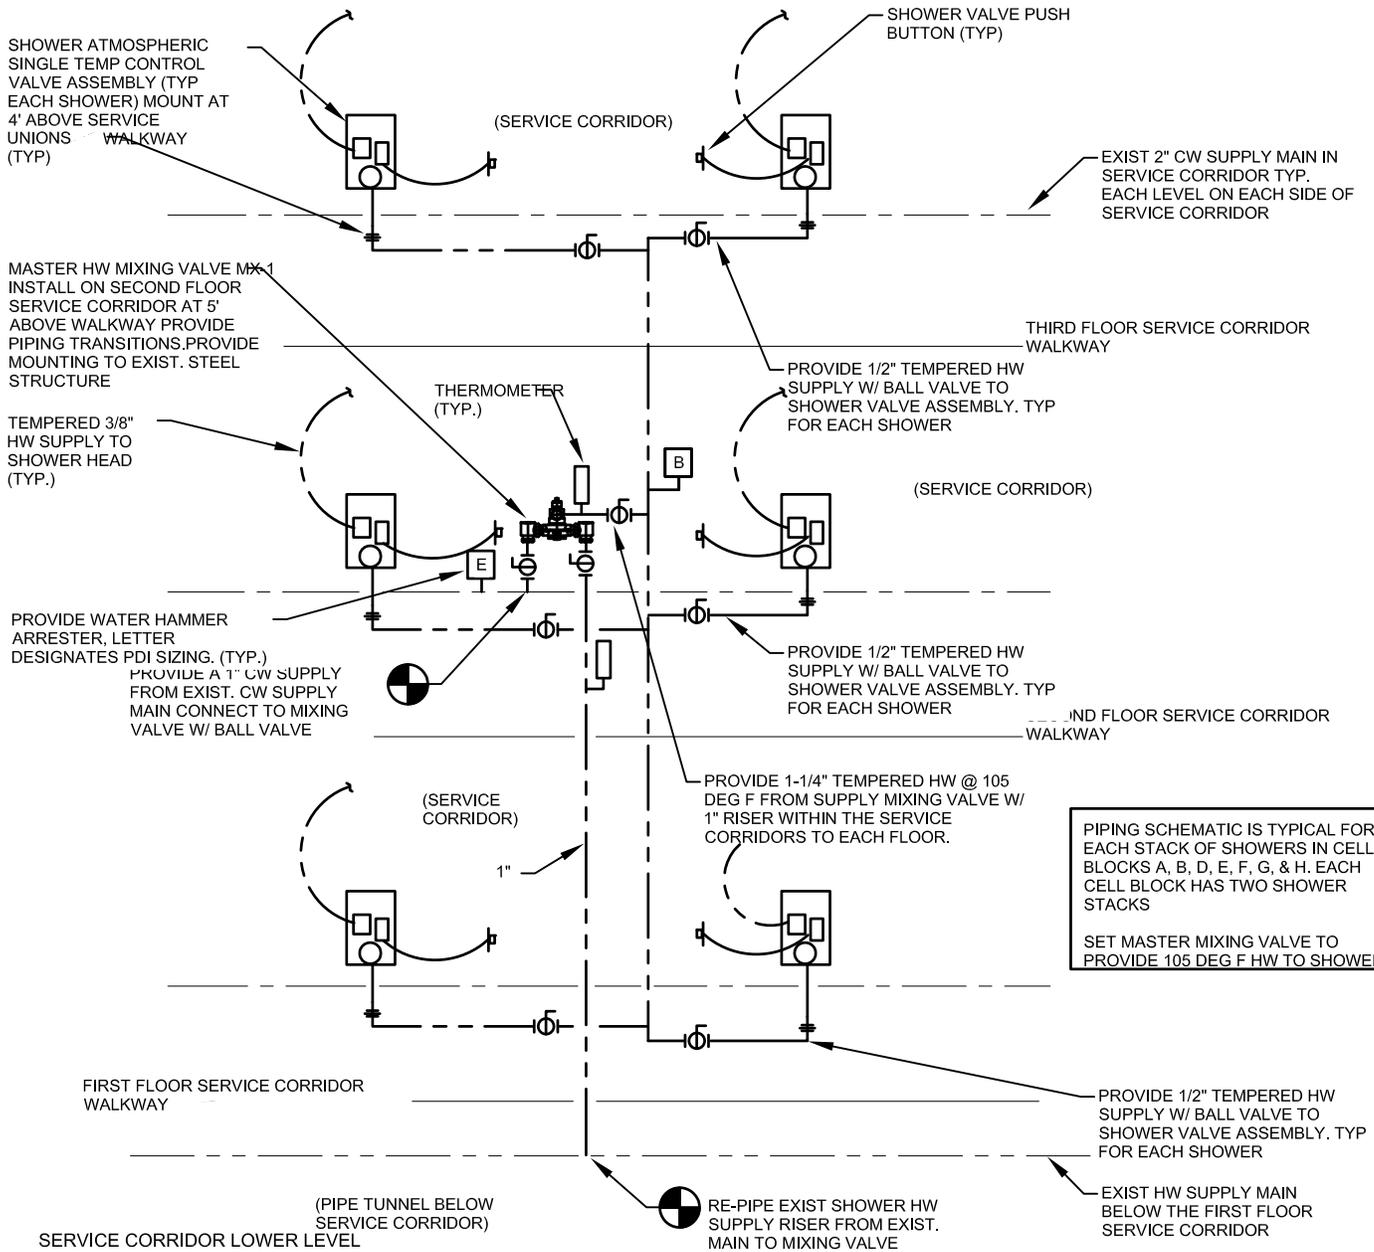

# 1 TYPICAL SHOWER PIPING SCHEMATIC

P-SK2 SCALE: N.T.S.



860 Hooper Road  
 Endwell, New York 13760  
 Tel: 607.231.6600  
 Fax: 607.231.6651  
 Email: mail@deltaengineers.com  
 Web: www.deltaengineers.com  
 DELTA PROJECT NUMBER: 2010.589.022

CONTRACT: **PLUMBING**  
 PROJ. NO: **44532**  
 DATE: **01-07-2015**  
 DRAWN: **KLB**  
 APPROVED: **TAC**

REFERENCE DRAWING: **P-001**

SHEET TITLE:  
**ADDENDUM #1  
 SHOWER PIPING SCHEMATIC**

PROJECT: **REHABILITATE SHOWERS  
 BLOCKS A, B, C, D, E, F, G, & H  
 GREEN HAVEN CORRECTIONAL FACILITY**

THE ALTERATION OF THIS MATERIAL IN ANY WAY, UNLESS DONE UNDER THE DIRECTION OF A COMPARABLE PROFESSIONAL, I.E. ARCHITECT FOR AN ARCHITECT, ENGINEER FOR AN ENGINEER OR LANDSCAPE ARCHITECT FOR A LANDSCAPE ARCHITECT, IS A VIOLATION OF THE NEW YORK STATE EDUCATION LAW AND/OR REGULATIONS AND IS A CLASS 'A' MISDEMEANOR.

DWG NO:  
**P-SK2**