



STATE OF NEW YORK  
OFFICE OF GENERAL SERVICES  
DESIGN AND CONSTRUCTION GROUP  
THE GOVERNOR NELSON A. ROCKEFELLER  
EMPIRE STATE PLAZA  
ALBANY, NY 12242



---

---

**ADDENDUM NO. 1 TO PROJECT NO. 44534**

**CONSTRUCTION WORK AND ELECTRIC WORK  
REHABILITATION OF WATER TREATMENT FILTERS  
GREAT MEADOW CORRECTIONAL FACILITY  
DEPARTMENT OF CORRECTIONS AND COMMUNITY SUPERVISION  
COMSTOCK, NEW YORK**

November 26, 2013

**NOTE:** This Addendum forms a part of the Contract Documents. Insert it in the Project Manual.  
Acknowledge receipt of this Addendum in the space provided on the Bid Form.

**CONSTRUCTION WORK DRAWINGS**

1. Drawing numbers C-100, C-101, C-102, and C-103 accompany this addendum and supersede the same numbered originally issued drawings. The addendum is being issued because the photos in the originally issued drawings were not clear.

**END OF ADDENDUM**

James Dirolf, P.E.  
Director of Design



CONSULTANT

**C&S**  
COMPANIES  
C&S Engineers, Inc.  
499 Col. Eileen Collins Blvd.  
Syracuse, New York 13212  
Phone: 315-455-2000  
Fax: 315-455-9667  
www.cscos.com



**WARNING:**  
THE ALTERATION OF THIS MATERIAL IN ANY WAY, UNLESS DONE UNDER THE DIRECTION OF A COMPARABLE PROFESSIONAL, I.E. ARCHITECT FOR AN ARCHITECT, ENGINEER FOR AN ENGINEER OR LANDSCAPE ARCHITECT FOR A LANDSCAPE ARCHITECT, IS A VIOLATION OF THE NEW YORK STATE EDUCATION LAW AND/OR REGULATIONS AND IS A CLASS "A" MISDEMEANOR.

**CONSTRUCTION**

TITLE:  
REHABILITATE WATER FILTER TANKS  
AND SYSTEM COMPONENTS

LOCATION:  
GREAT MEADOW CORRECTIONAL FACILITY  
11739 NYS ROUTE 22  
COMSTOCK, NEW YORK 12821

CLIENT:


08/16/2013 BID DOCUMENTS

MARK	DATE	DESCRIPTION
PROJECT NUMBER:	<b>44534 - C</b>	
DESIGNED BY:	R. JACKSON	
DRAWN BY:	R. JACKSON	
FIELD CHECK:		
APPROVED:		

SHEET TITLE:  
**WATER TREATMENT PLANT  
EXISTING CONDITIONS  
PLAN - PHOTOS**

DRAWING NUMBER:  
**C-101**

SHEET OF

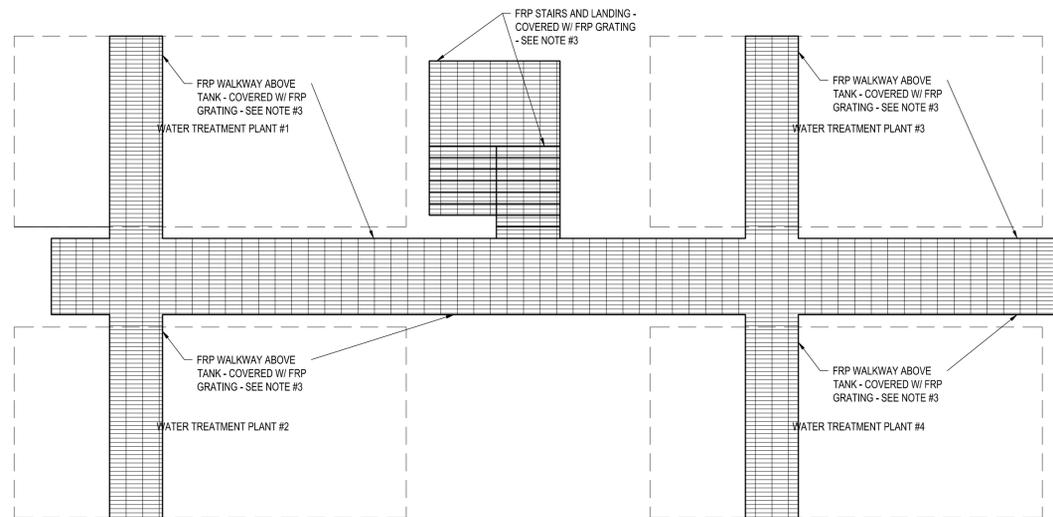

- NOTES:
- 3'-6" HIGH HANDRAILS ARE LOCATED ALL AROUND THE EXTERIOR OF THE WALKWAYS AND STAIRS.
  - SUPPORT POSTS BELOW ARE NOT SHOWN.
  - CONTRACTOR SHALL REMOVE, PROTECT AND REPLACE AS NECESSARY TO COMPLETE THE WORK OF THIS CONTRACT.

- NOTES:
- SEE DRAWING C-100 FOR PHOTO LOCATION PLAN.


**A1 EXISTING WALKWAY LOCATION PLAN**  
SCALE: 1/4" = 1'-0"



**WARNING:**  
 THE ALTERATION OF THIS MATERIAL IN ANY WAY, UNLESS DONE UNDER THE DIRECTION OF A COMPARABLE PROFESSIONAL, I.E. ARCHITECT FOR AN ARCHITECT, ENGINEER FOR AN ENGINEER OR LANDSCAPE ARCHITECT FOR A LANDSCAPE ARCHITECT, IS A VIOLATION OF THE NEW YORK STATE EDUCATION LAW AND/OR REGULATIONS AND IS A CLASS "A" MISDEMEANOR.

CONTRACT:  
**CONSTRUCTION**  
 TITLE:  
 REHABILITATE WATER FILTER TANKS AND SYSTEM COMPONENTS  
 LOCATION:  
 GREAT MEADOW CORRECTIONAL FACILITY  
 11739 NYS ROUTE 22  
 COMSTOCK, NEW YORK 12821  
 CLIENT:

MARK	08/16/2013	BID DOCUMENTS
PROJECT NUMBER:	<b>44534 - C</b>	
DESIGNED BY:	R. JACKSON	
DRAWN BY:	R. JACKSON	
FIELD CHECK:		
APPROVED:		
SHEET TITLE:	<b>WATER TREATMENT PLANT DEMOLITION PLAN</b>	
DRAWING NUMBER:	<b>C-102</b>	
SHEET		OF

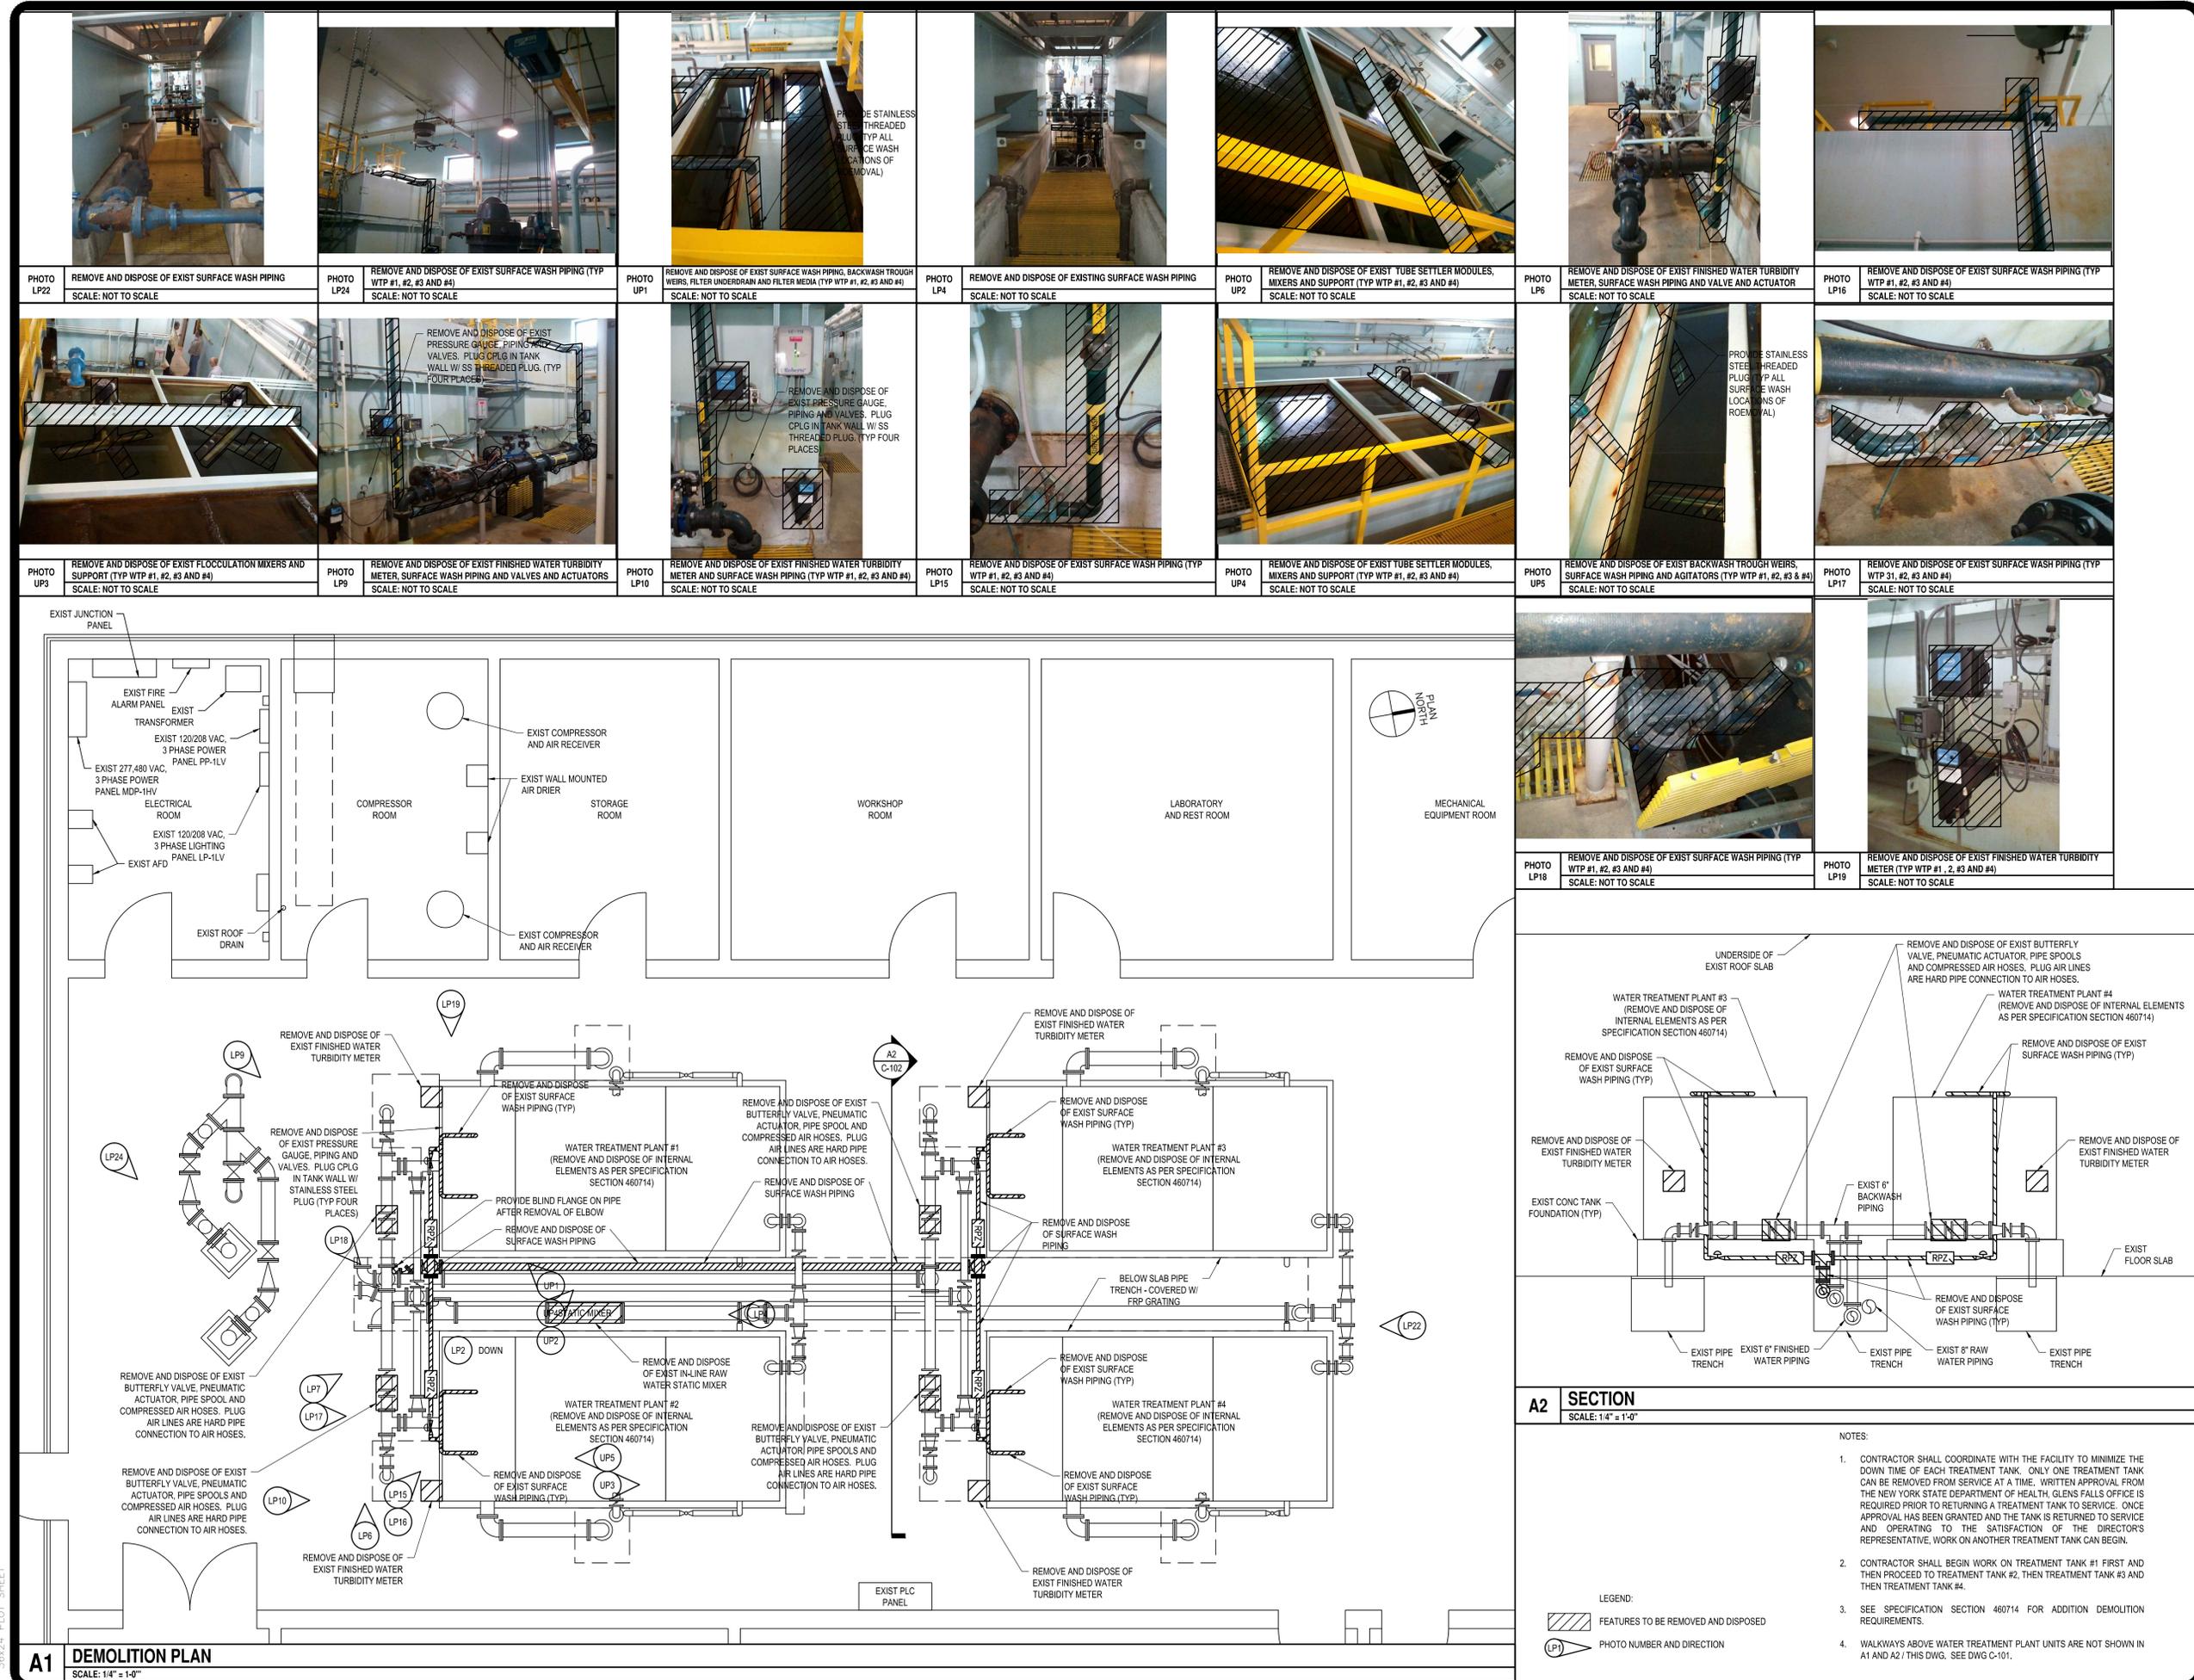

Nov 25, 2013 11:14am  
 F:\Project\190 - NYS065\190429053 - Great Meadow CF Water Filtration Rehab\Design\CADD\Sheet Files\Construction\Contract\190429053 C-102.dwg  
 36x24 PLOT SHEET



**WARNING:**  
THE ALTERATION OF THIS MATERIAL IN ANY WAY, UNLESS DONE UNDER THE DIRECTION OF A COMPARABLE PROFESSIONAL, I.E. ARCHITECT FOR AN ARCHITECT, ENGINEER FOR AN ENGINEER OR LANDSCAPE ARCHITECT FOR A LANDSCAPE ARCHITECT, IS A VIOLATION OF THE NEW YORK STATE EDUCATION LAW AND/OR REGULATIONS AND IS A CLASS "A" MISDEMEANOR.







**CONSTRUCTION**  
TITLE: REHABILITATE WATER FILTER TANKS AND SYSTEM COMPONENTS  
LOCATION: GREAT MEADOW CORRECTIONAL FACILITY  
11739 NYS ROUTE 22  
COMSTOCK, NEW YORK 12821  
CLIENT:

MARK	DATE	DESCRIPTION
	08/16/2013	BID DOCUMENTS
PROJECT NUMBER:	<b>44534 - C</b>	
DESIGNED BY:	R. JACKSON	
DRAWN BY:	R. JACKSON	
FIELD CHECK:		
APPROVED:		
SHEET TITLE:	<b>WATER TREATMENT PLANT PROCESS EQUIPMENT AND PIPING PLAN</b>	
DRAWING NUMBER:	<b>C-103</b>	
SHEET	OF	

VALVE SCHEDULE				
UNIT NUMBER	LOCATION	SIZE (INCH)	TYPE	SPECIFICATION SECTION
VBF-1, 2, 3, 4	COMPRESSOR ROOM	2.5	INDUSTRIAL BUTTERFLY	220523
VBF-5, 6, 7, 8	ABOVE WATER TREATMENT PLANT TANKS	2.5	INDUSTRIAL BUTTERFLY	220523
VG-1	PIPE TRENCH BETWEEN WTP TANKS	8	RESILIENT SEATED GATE	220523
VPL-1, 2, 3, 4	BACKWASH WATER PIPING	6	ECCENTRIC PLUG	220523

EQUIPMENT SCHEDULE		
UNIT NUMBER	LOCATION	SPECIFICATION SECTION
STATIC MIXER 1	PIPE TRENCH BETWEEN WTP TANKS	464117
BLOWER 1, BLOWER 2	COMPRESSOR ROOM	466117

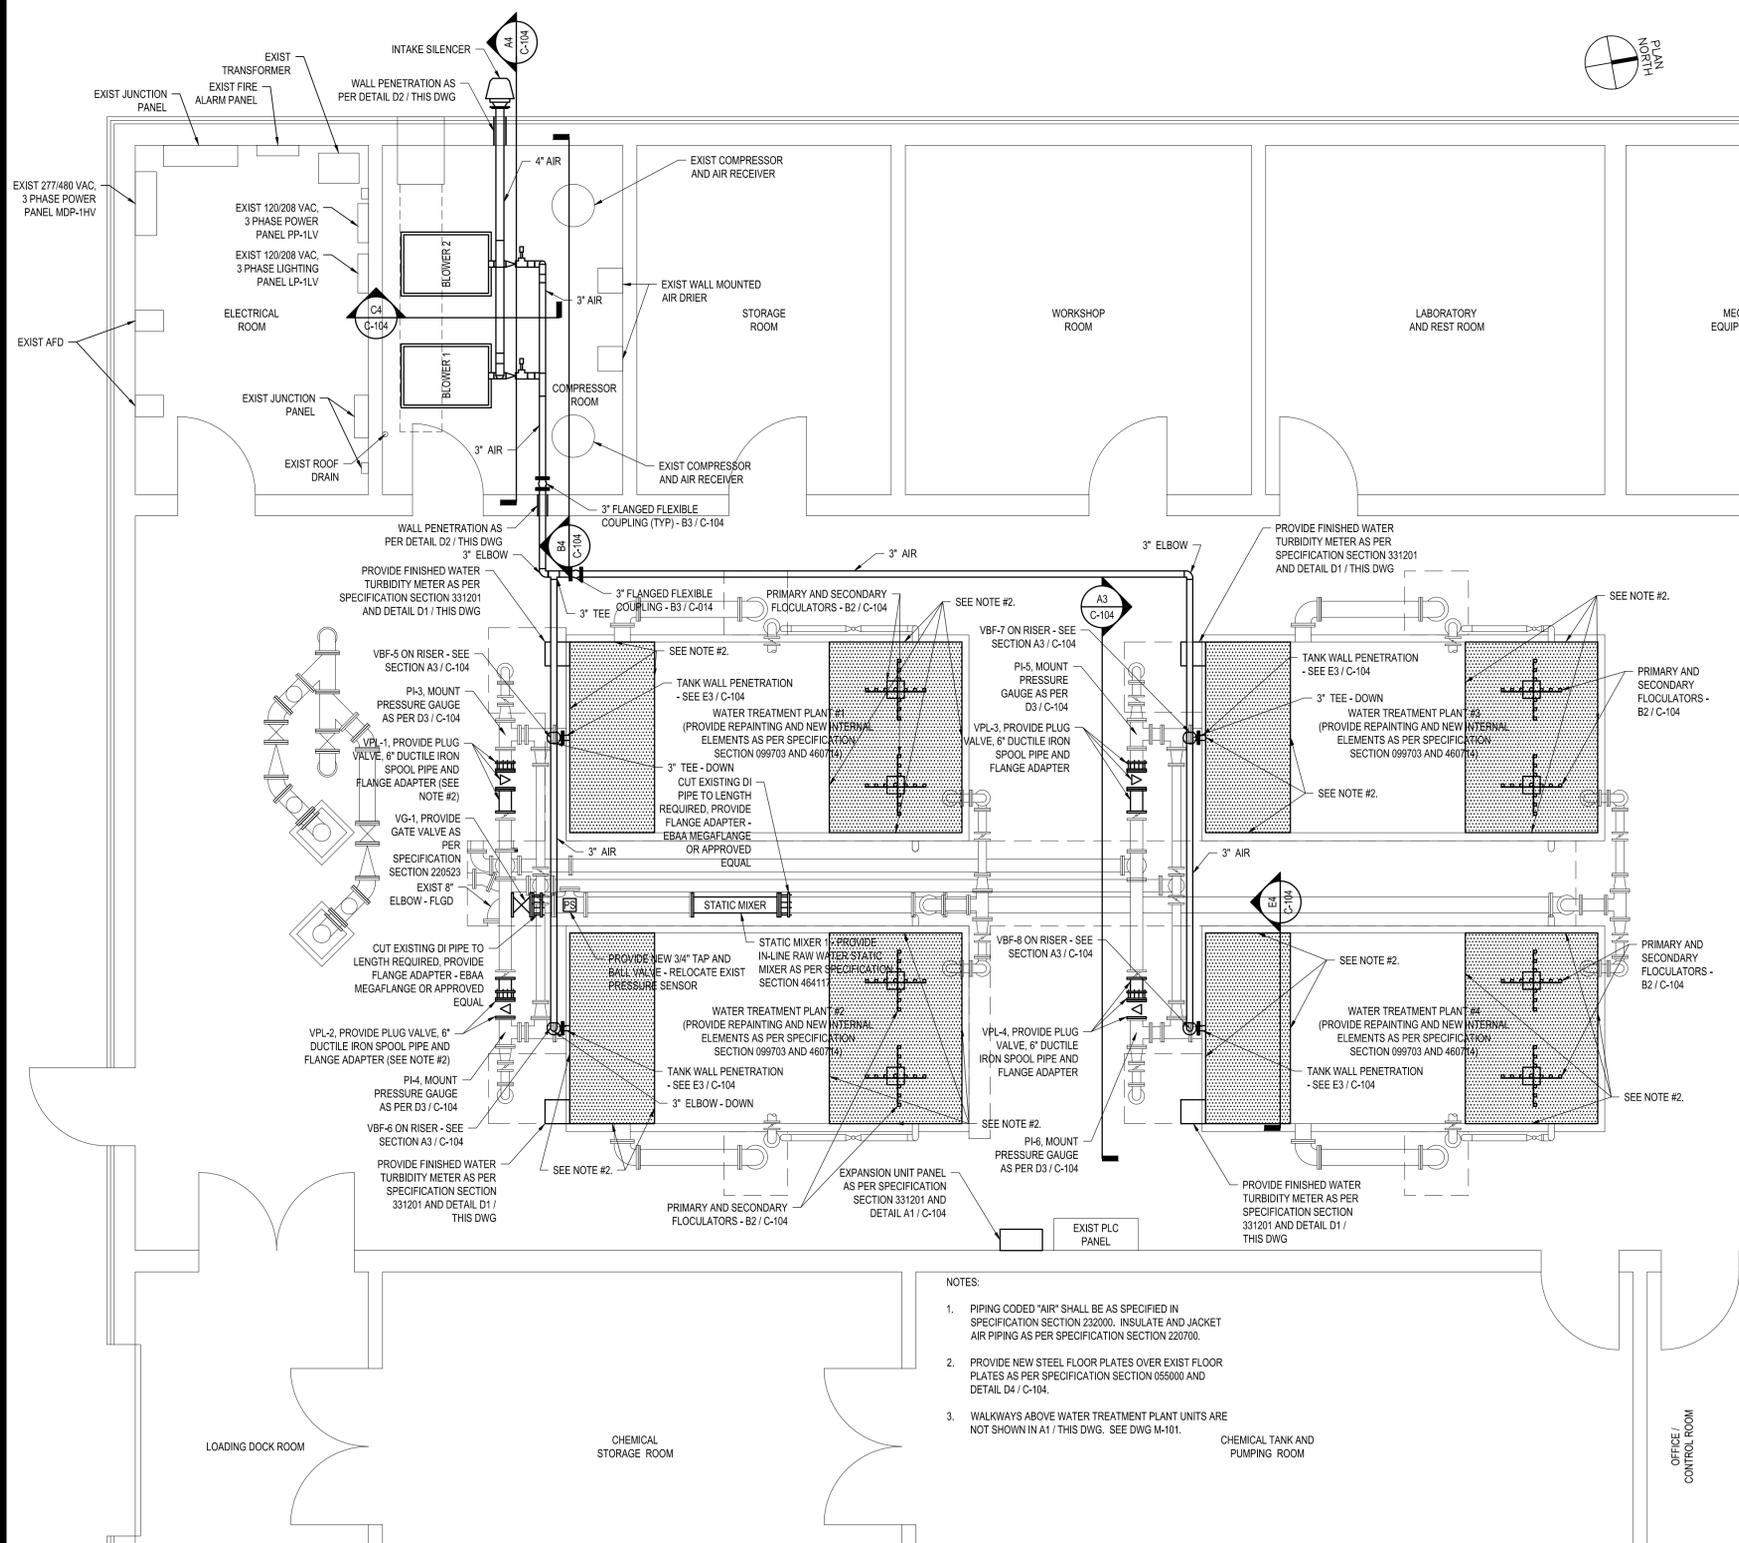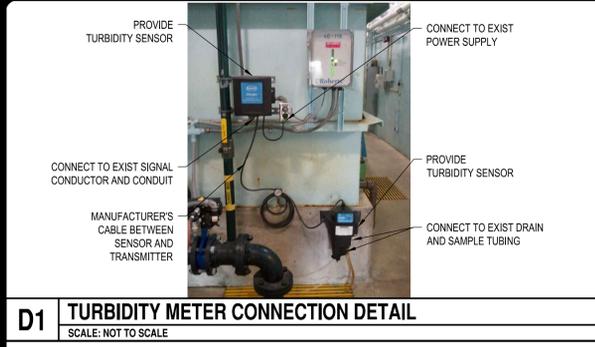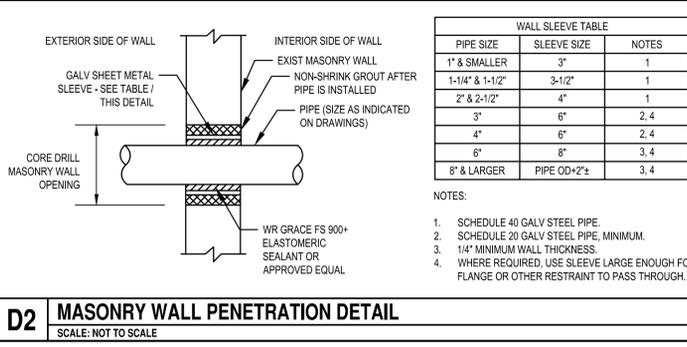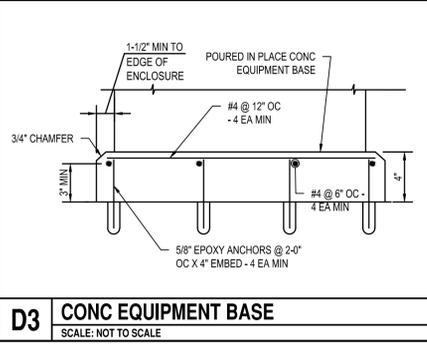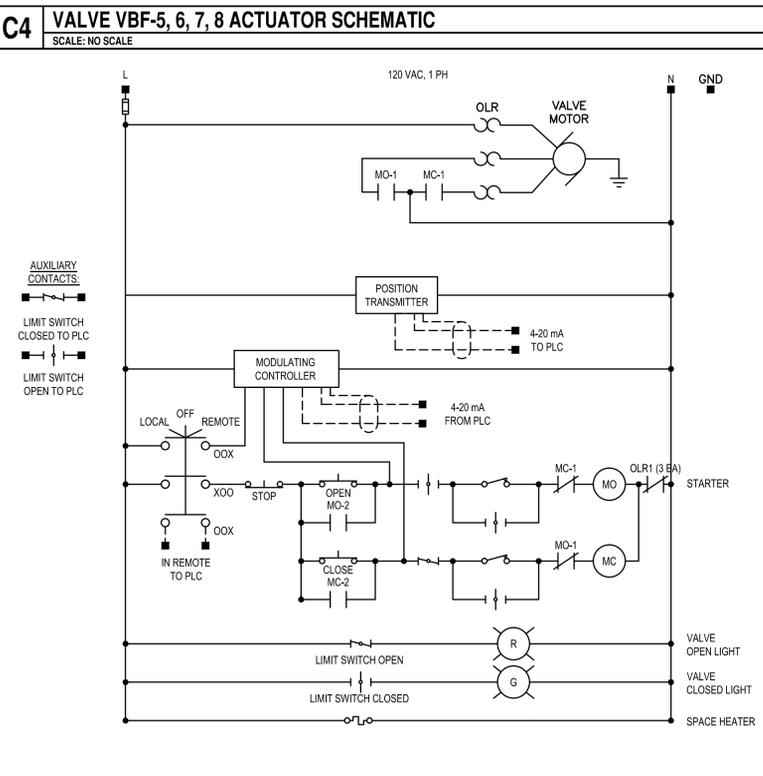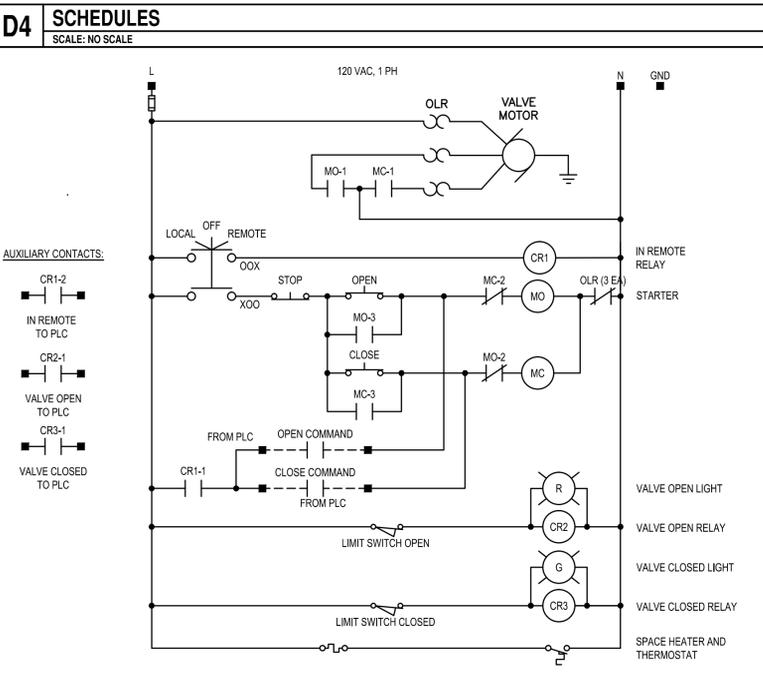

Nov 25, 2013 11:14am F:\Project\190 - NYS065\190429053 - Great Meadow CF Water Filtration Rehab\_Design\CADD\Sheet\_Files\Construction\_Contract\190429053 C-103.dwg 36x24 PLOT SHEET