



STATE OF NEW YORK
OFFICE OF GENERAL SERVICES
DESIGN AND CONSTRUCTION GROUP
THE GOVERNOR NELSON A. ROCKEFELLER
EMPIRE STATE PLAZA
ALBANY, NY 12242



ADDENDUM NO. 1 TO PROJECT NO. 44627

**CONSTRUCTION WORK, PLUMBING WORK, ELECTRIC WORK
UPGRADE OBSERVATION CELLS
FIRST FLOOR, BUILDING NO. 35
WENDE CORRECTIONAL FACILITY
3040 WENDE ROAD
ALDEN, NY**

May 11, 2015

NOTE: This Addendum forms a part of the Contract Documents. Insert it in the Project Manual.
Acknowledge receipt of this Addendum in the space provided on the Bid Form.

SPECIFICATION:

1. Page 011000 – 2, Add the following Paragraphs to Article 1.04 CONTRACT AWARD SUMITTALS:
 - F. Submittal No.5: Submit submittals per requirements of specification section 224600 – SECURITY PLUMBING FIXTURES within 45 days after approval of the Contract by the Comptroller.
 - G. Submittal No.6: Submit submittals per requirements of specification section 265110 – FLUORESCENT FIXTURES within 45 days after approval of the Contract by the Comptroller.


CONSTRUCTION WORK DRAWINGS

2. Drawing No. A-101
 - a. TITLE BLOCK: Change Project no. '44267-C' to read '44627-C'.
 - b. GENERAL NOTES: Add the following note:
 - “21. ALL BAR GRILLAGE PANELS AND DOORS SHALL BE FULLY ASSEMBLED PRIOR TO INSTALLATION, INCLUDING THE STAINLESS STEEL MESH SCREEN.”
3. Drawing No. A-102
 - a. TITLE BLOCK: Change Project no. '44267-C' to read '44627-C'.



4. Drawing No. A-501
 - a. TITLE BLOCK: Change Project no. '44267-C' to read '44627-C'.
 - b. DETAIL 8/A501: Replace 'DETAIL 8' per attached, revised detail on drawing no. ADD-1.
 - c. DETAIL 9/A501: Replace 'DETAIL 9' per attached, revised detail on drawing no. ADD-1.

END OF ADDENDUM

Margaret F. Larkin
Executive Director
Design and Construction

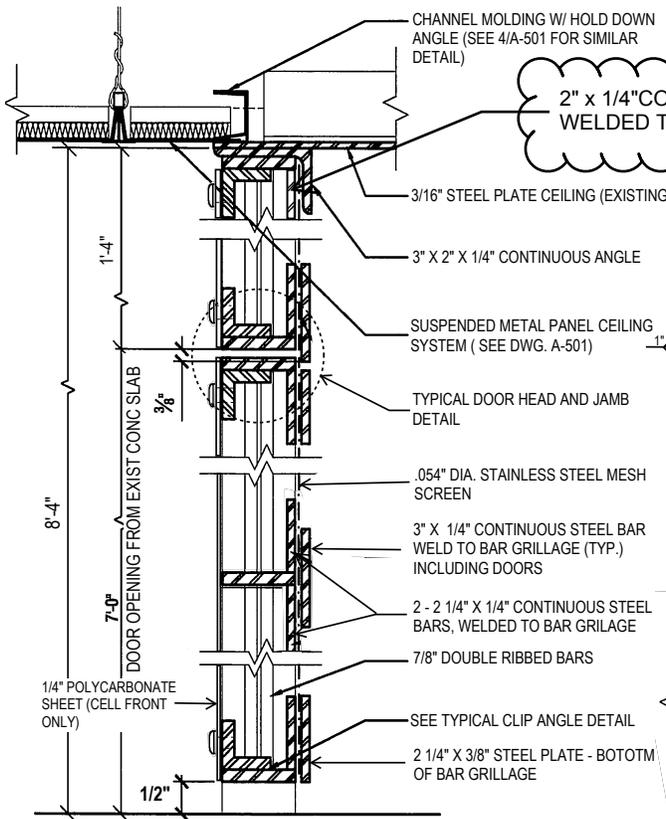

8
CELL DOOR TYPICAL DETAIL
 SCALE: NOT TO SCALE

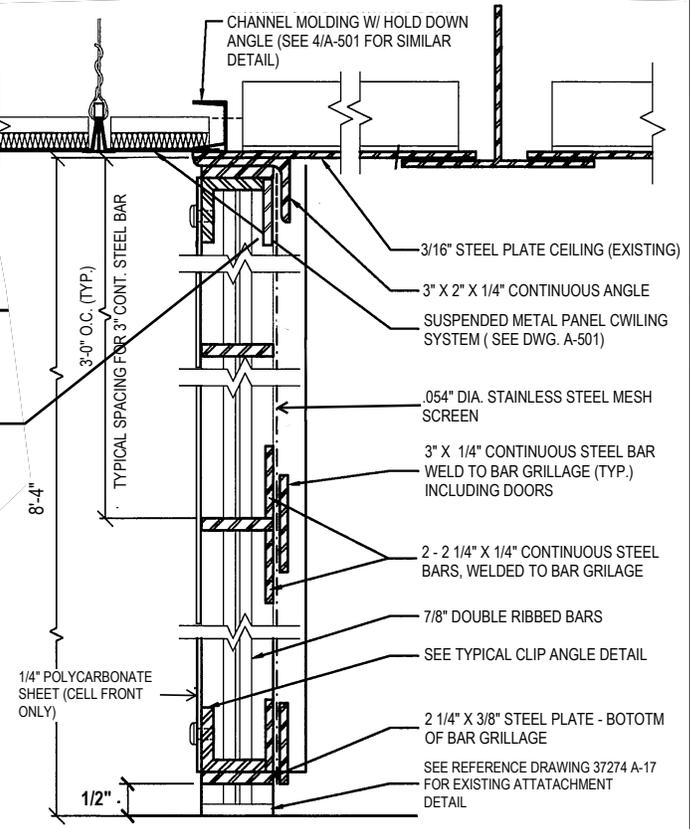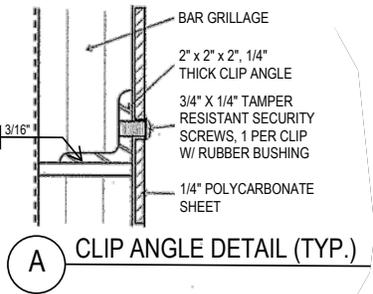

9
BAR GRILLAGE TYPICAL DETAIL
 SCALE: NOT TO SCALE



| | |
|-----------|--------------|
| CONTRACT: | CONSTRUCTION |
| PROJ. NO: | 44627-C |
| DATE: | 05/11/15 |
| DRAWN: | RES |
| APPROVED: | RES |

SHEET TITLE: REVISED DETAILS 8 & 9/A501
 CELL DOOR TYPICAL DETAIL
 BAR GRILLAGE TYPICAL DETAIL

PROJECT: UPGRADE OBSERVATION CELLS
 BUILDING NO. 35
 WENDE CORRECTIONAL FACILITY

WARNING: THE ALTERATION OF THIS MATERIAL IN ANY WAY, UNLESS DONE UNDER THE DIRECTION OF A COMPARABLE PROFESSIONAL, I.E. ARCHITECT FOR AN ARCHITECT, ENGINEER FOR AN ENGINEER OR LANDSCAPE ARCHITECT FOR A LANDSCAPE ARCHITECT, IS A VIOLATION OF THE NEW YORK STATE EDUCATION LAW AND/OR REGULATIONS AND IS A CLASS 'A' MISDEMEANOR.

DWG NO:
 ADD 1