



STATE OF NEW YORK
OFFICE OF GENERAL SERVICES
DESIGN AND CONSTRUCTION GROUP
THE GOVERNOR NELSON A. ROCKEFELLER
EMPIRE STATE PLAZA
ALBANY, NY 12242



ADDENDUM NO. 3 TO PROJECT NO. 44835

**CONSTRUCTION WORK, HVAC WORK, PLUMBING WORK & ELECTRICAL WORK:
PROVIDE PERIMETER FENCE SYSTEMS, BUILDINGS & SITE IMPROVEMENTS
WALLKILL CORRECTIONAL FACILITY
ROUTE 208
WALLKILL, NY 12589-0286**

March 17, 2016



NOTE: This Addendum forms a part of the Contract Documents. Insert it in the Project Manual.
Acknowledge receipt of this Addendum in the space provided on the Bid Form.

DRAWINGS

1. Reissued Drawings:
 - a. Drawing Nos. E-251, E-252, E-253 and E-254: Discard Drawing Nos. E-251, E-252, E-253 and E-254 bound in the Contract Documents and substitute the attached Drawing Nos. E-251, E-252, E-253 and E-254.

END OF ADDENDUM

Margaret F. Larkin
Executive Director
Design and Construction

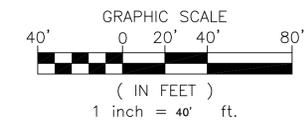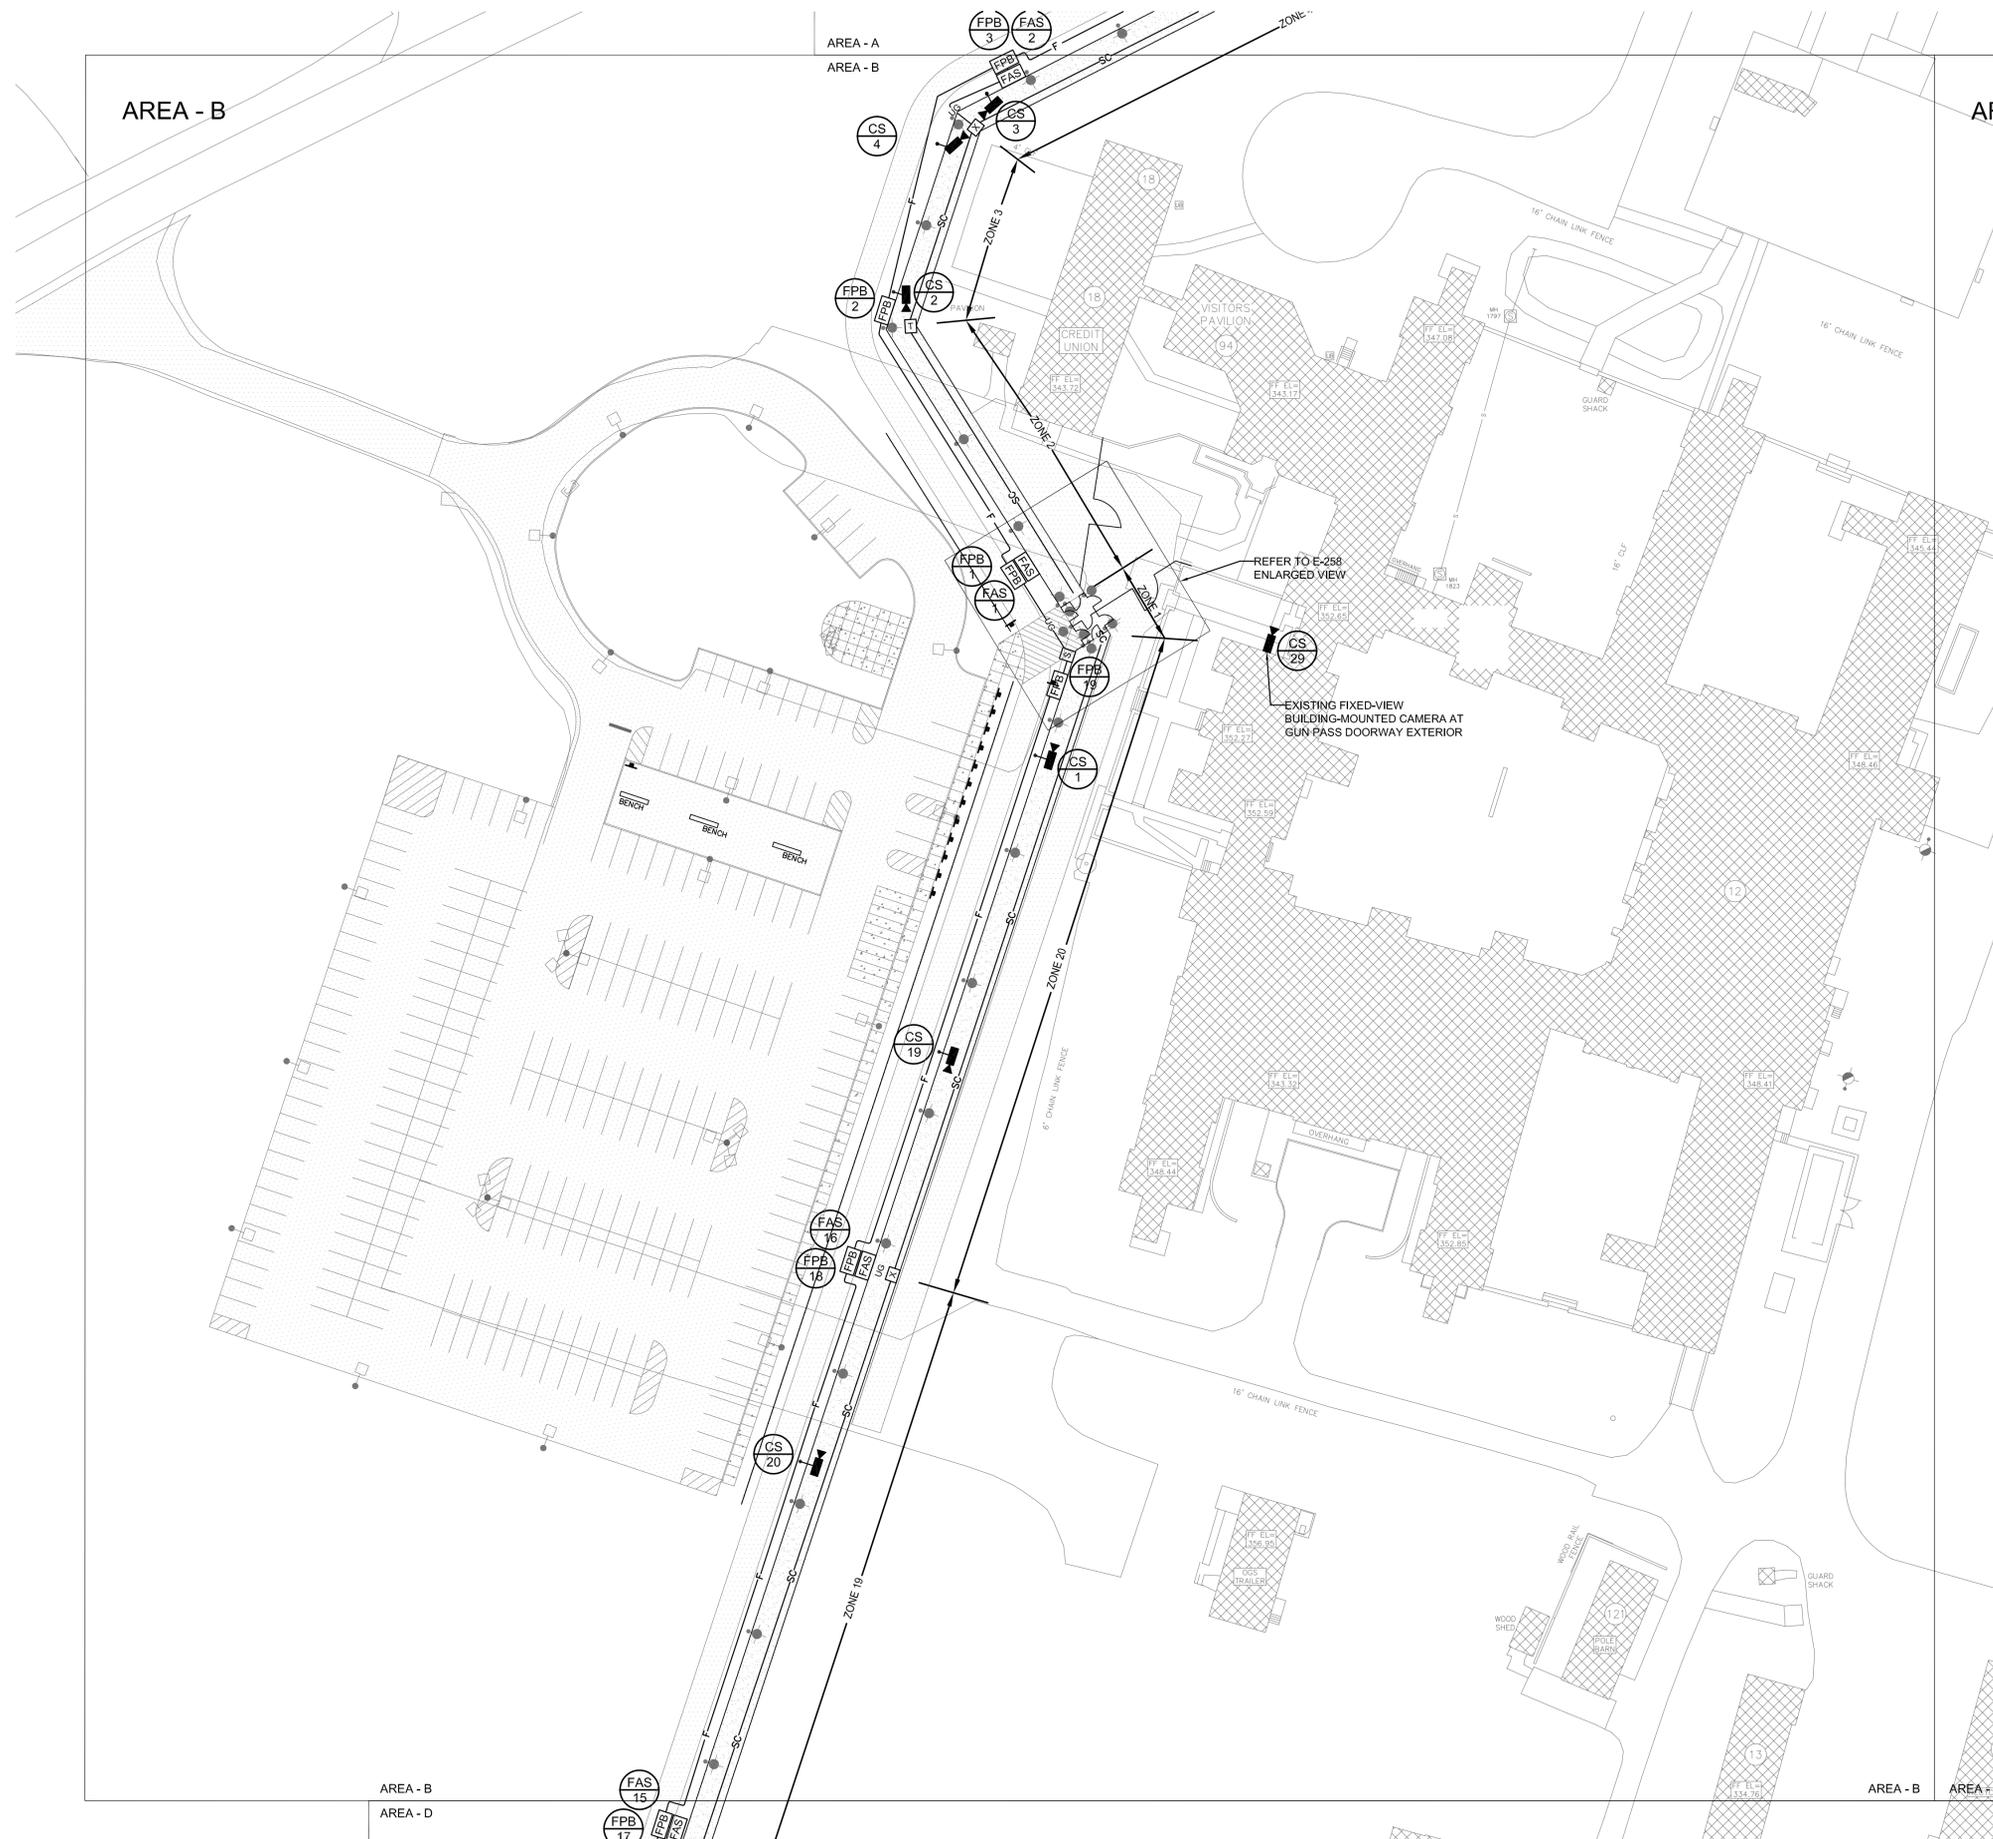

NOTE:
 HORN SPEAKERS NOT SHOWN TO MAINTAIN CLARITY. REFER TO E-450, NOTE 7.

CONSULTANT
SMRT
 ARCHITECTURE
 ENGINEERING
 PLANNING
 INTERIOR DESIGN
 COMMISSIONING
 SMRT Architects and Engineers, PC
 11 Century Hill Drive, Suite 207
 Latham, NY 12110-2162

VANDERWEIL
 R.G. Vanderweil Engineers, LLP
 274 Summer Street
 Boston, MA 02210



WARNING:
 THE ALTERATION OF THIS MATERIAL IN ANY WAY, UNLESS DONE UNDER THE DIRECTION OF A COMPARABLE PROFESSIONAL, I.E. ARCHITECT FOR AN ARCHITECT, ENGINEER FOR AN ENGINEER OR LANDSCAPE ARCHITECT FOR A LANDSCAPE ARCHITECT, IS A VIOLATION OF THE NEW YORK STATE EDUCATION LAW AND/OR REGULATIONS AND IS A CLASS 'A' MISDEMEANOR.



CONTRACT: **ELECTRICAL**
 TITLE: **PROVIDE PERIMETER FENCE/SYSTEMS, BUILDINGS & SITE IMPROVEMENTS**
 LOCATION: **WALKKILL CORRECTIONAL FACILITY, ROUTE 208, WALKKILL, NY**
 CLIENT: **DEPARTMENT OF CORRECTIONS AND COMMUNITY SUPERVISION**

MARK	DATE	DESCRIPTION
	01/27/16	FOR BID
PROJECT NUMBER:	44835 - E	
DESIGNED BY:	RL	
DRAWN BY:	RF	
FIELD CHECK:		
APPROVED:		

SHEET TITLE:
PERIMETER SECURITY PLAN AREA - B
 DRAWING NUMBER:
E-252
 SHEET 115 of 140

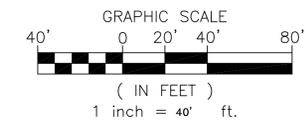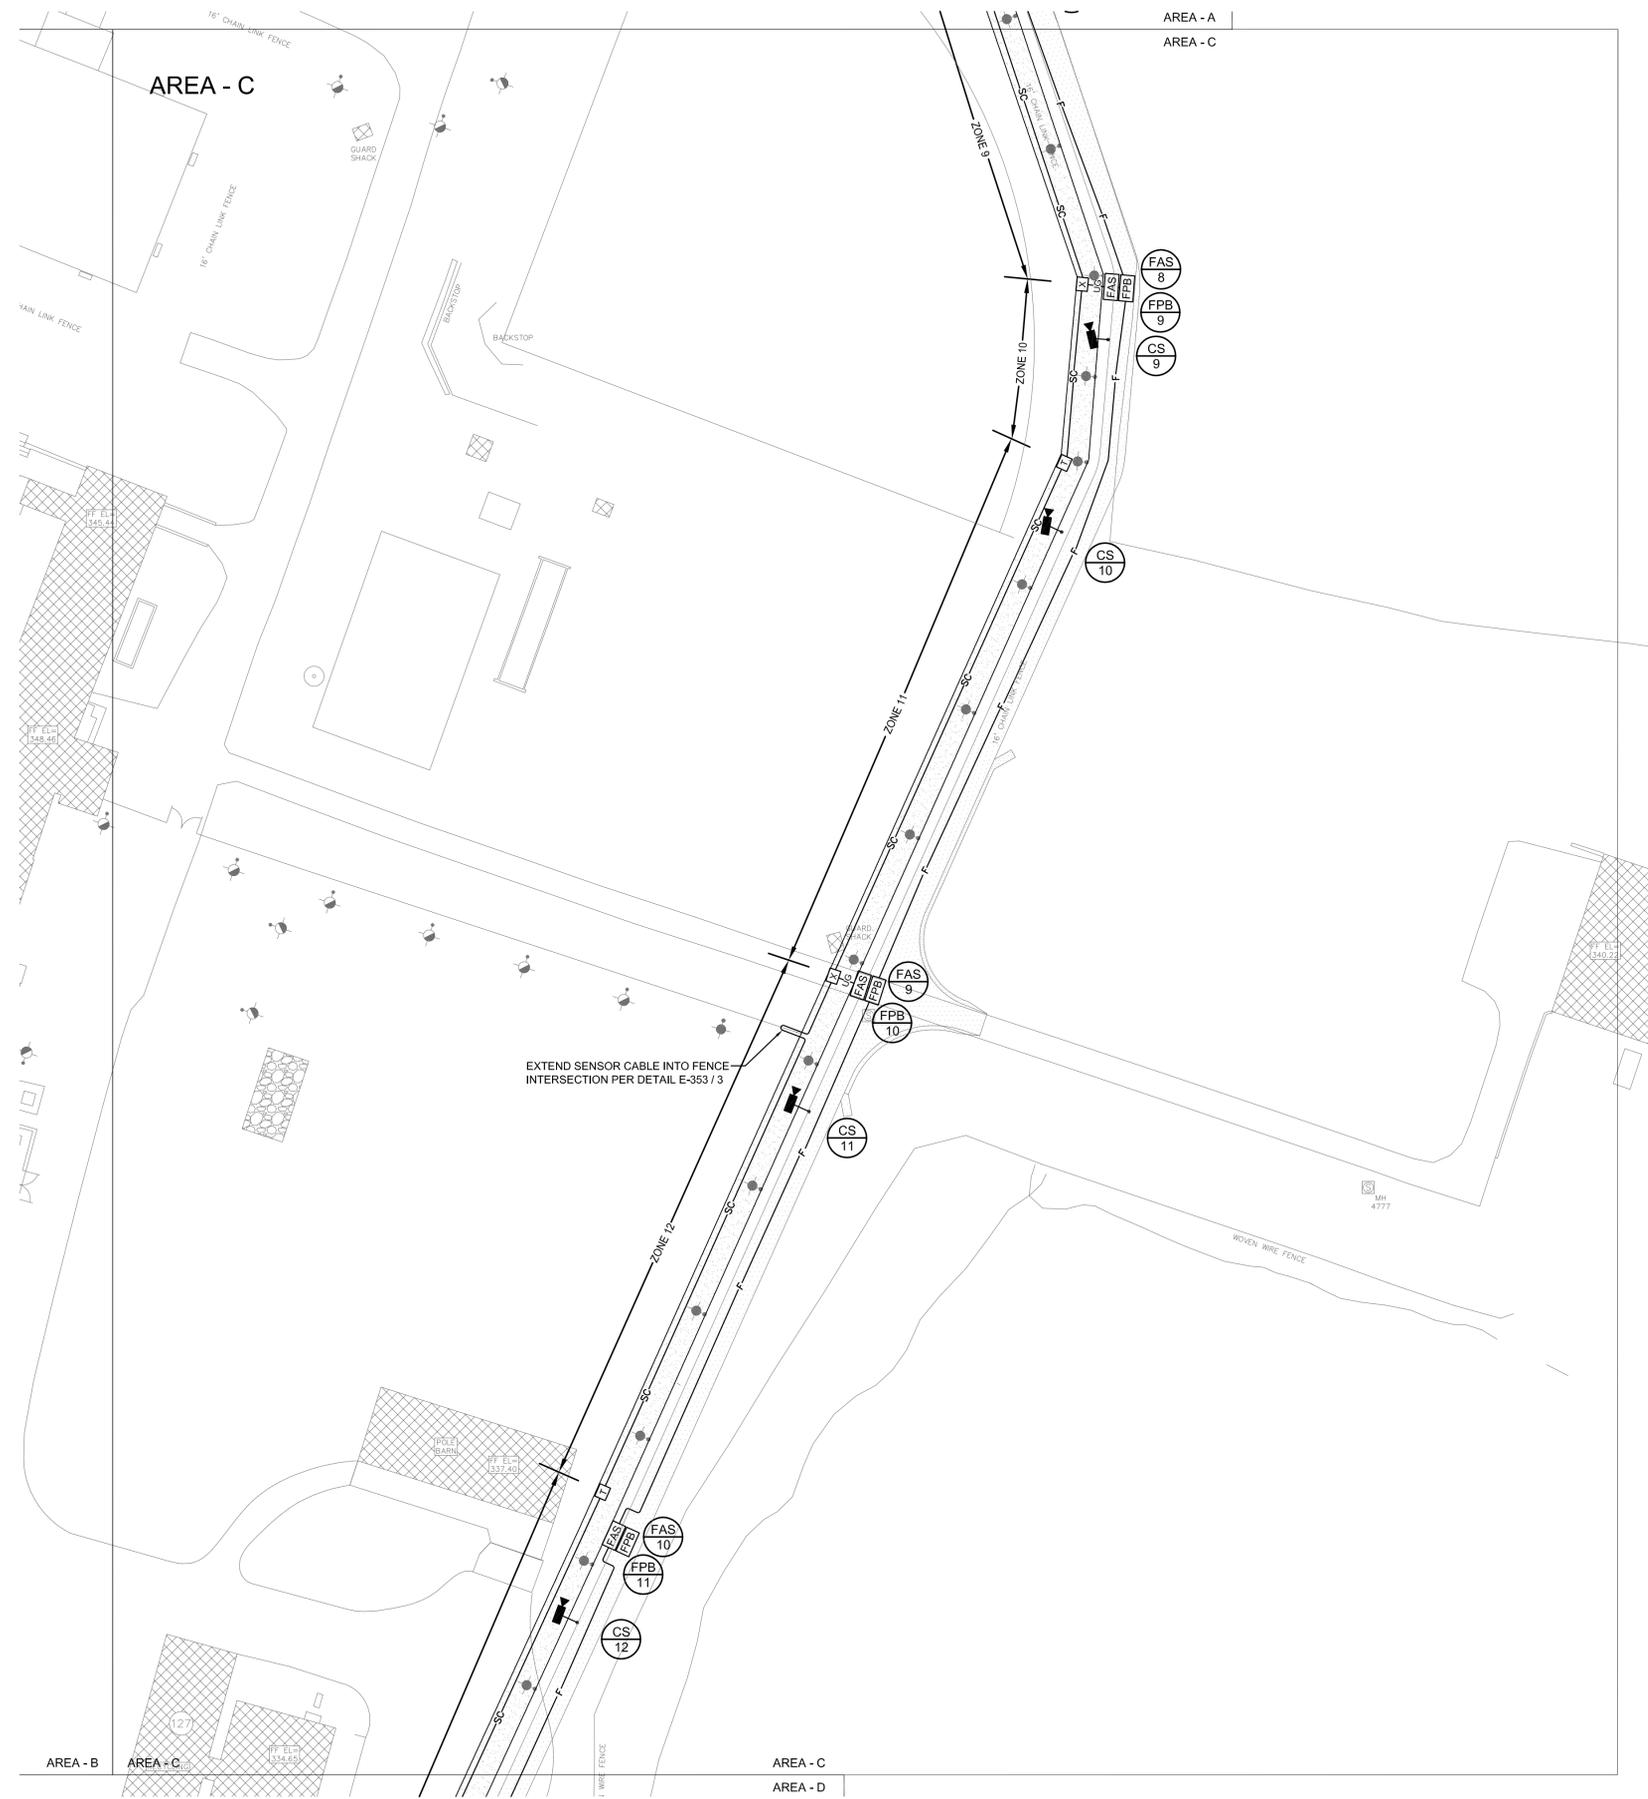

NOTE:
 HORN SPEAKERS NOT SHOWN TO MAINTAIN CLARITY. REFER TO E-450, NOTE 7.

CONSULTANT
SMRT
 ARCHITECTURE
 ENGINEERING
 PLANNING
 INTERIOR DESIGN
 COMMISSIONING
 SMRT Architects and Engineers, PC
 11 Century Hill Drive, Suite 207
 Latham, NY 12110-2162

VANDERWEIL
 R.G. Vanderweil Engineers, LLP
 274 Summer Street
 Boston, MA 02210

WARNING:
 THE ALTERATION OF THIS MATERIAL IN ANY WAY, UNLESS DONE UNDER THE DIRECTION OF A COMPARABLE PROFESSIONAL, I.E. ARCHITECT FOR AN ARCHITECT, ENGINEER FOR AN ENGINEER OR LANDSCAPE ARCHITECT FOR A LANDSCAPE ARCHITECT, IS A VIOLATION OF THE NEW YORK STATE EDUCATION LAW AND/OR REGULATIONS AND IS A CLASS 'A' MISDEMEANOR.



CONTRACT: **ELECTRICAL**
 TITLE: PROVIDE PERIMETER FENCE/SYSTEMS, BUILDINGS & SITE IMPROVEMENTS
 LOCATION: WALLKILL CORRECTIONAL FACILITY, ROUTE 208, WALLKILL, NY
 CLIENT: DEPARTMENT OF CORRECTIONS AND COMMUNITY SUPERVISION

MARK	DATE	DESCRIPTION
	01/27/16	FOR BID
PROJECT NUMBER:	44835 - E	
DESIGNED BY:	RL	
DRAWN BY:	RF	
FIELD CHECK:		
APPROVED:		
SHEET TITLE:		
PERIMETER SECURITY PLAN AREA - C		
DRAWING NUMBER: E-253		
SHEET 116 of 140		



NYS OFFICE OF GENERAL SERVICES

Serving New York

ANDREW M. CUOMO
Governor
ROAYN M. DESTITO
Commissioner

CONSULTANT

ARCHITECTURE
ENGINEERING
PLANNING
INTERIOR DESIGN
COMMISSIONING



SMRT Architects and Engineers, PC
11 Century Hill Drive, Suite 207
Latham, NY 12110-2162



R.G. Vanderweil Engineers, LLP
274 Summer Street
Boston, MA 02210

WARNING:

THE ALTERATION OF THIS MATERIAL IN ANY WAY, UNLESS DONE UNDER THE DIRECTION OF A COMPARABLE PROFESSIONAL, I.E. ARCHITECT FOR AN ARCHITECT, ENGINEER FOR AN ENGINEER OR LANDSCAPE ARCHITECT FOR A LANDSCAPE ARCHITECT, IS A VIOLATION OF THE NEW YORK STATE EDUCATION LAW AND/OR REGULATIONS AND IS A CLASS 'A' MISDEMEANOR.





CONTRACT:

ELECTRICAL

TITLE:
PROVIDE PERIMETER FENCE/SYSTEMS,
BUILDINGS & SITE IMPROVEMENTS

LOCATION:
WALLKILL CORRECTIONAL FACILITY
ROUTE 208
WALLKILL, NY

CLIENT:
DEPARTMENT OF CORRECTIONS
AND COMMUNITY SUPERVISION

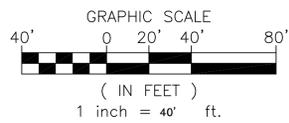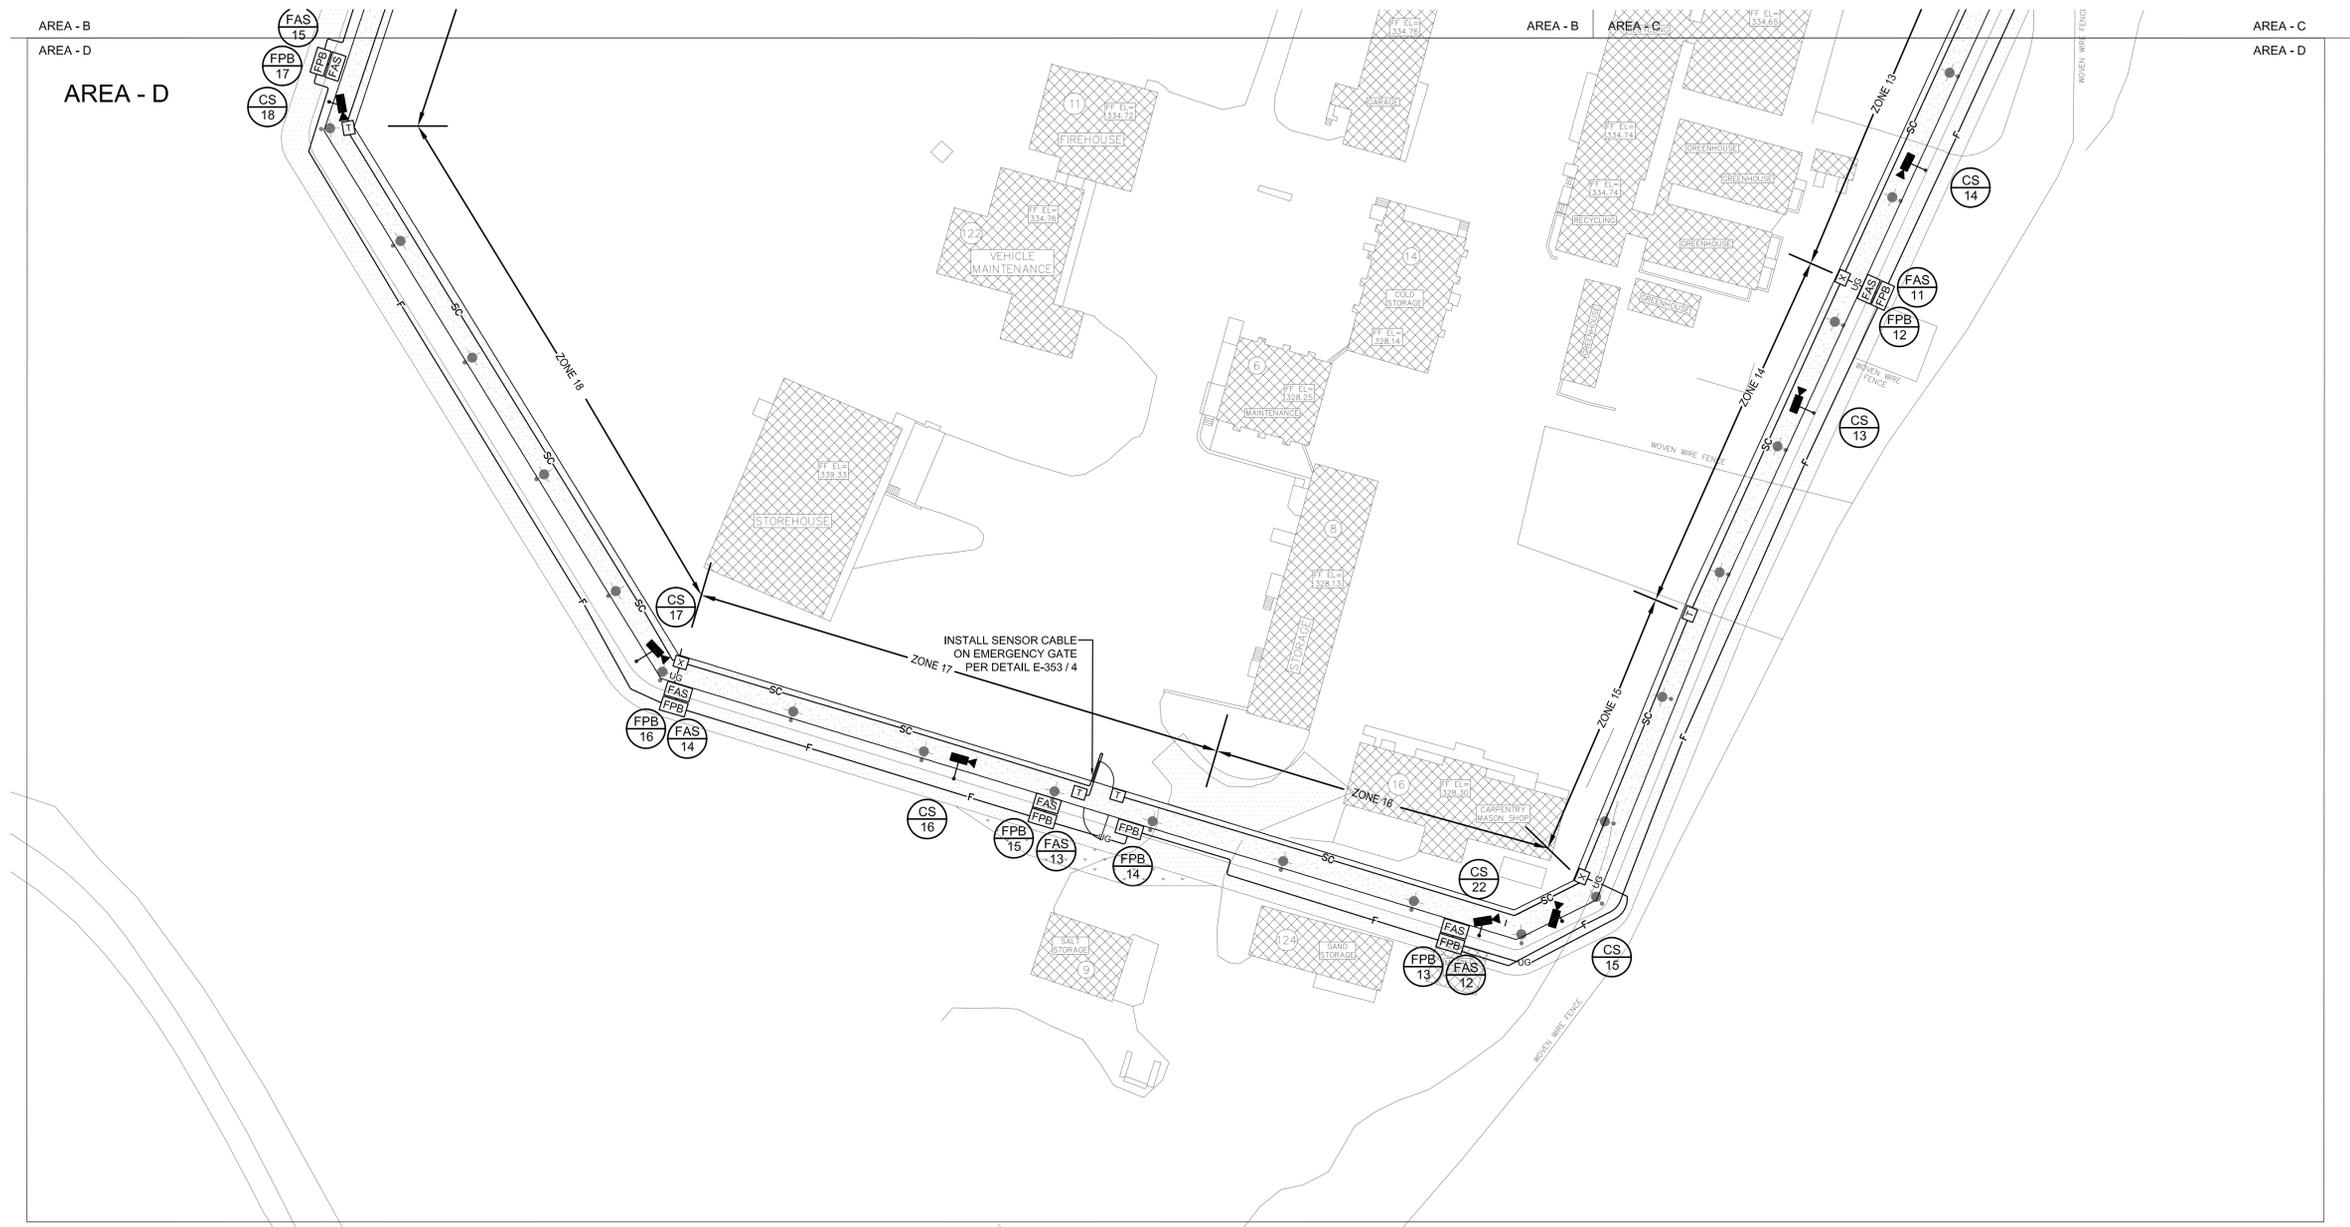

NOTE:
HORN SPEAKERS NOT SHOWN TO MAINTAIN CLARITY. REFER TO E-450, NOTE 7.

MARK	DATE	DESCRIPTION
	01/27/16	FOR BID
PROJECT NUMBER:	44835 - E	
DESIGNED BY:	RL	
DRAWN BY:	RF	
FIELD CHECK:		
APPROVED:		

SHEET TITLE:
PERIMETER SECURITY PLAN
AREA - D

DRAWING NUMBER:
E-254