



Office of General Services

DESIGN & CONSTRUCTION GROUP
THE GOVERNOR NELSON A. ROCKEFELLER
EMPIRE STATE PLAZA
ALBANY, NY 12242

ADDENDUM NO. 2 TO PROJECT NO. Q1910

CONSTRUCTION AND ELECTRICAL WORK REPLACE PERIMETER DETECTION & CAMERA SYSTEMS WENDE CORRECTIONAL FACILITY 3040 WENDE ROAD ALDEN, NY

February 26, 2026

NOTE: This Addendum forms a part of the Contract Documents. Insert it in the Project Manual. Acknowledge receipt of this Addendum in the space provided on the Bid Form.


ELECTRICAL DRAWINGS

1. Revised Drawing:
 - a. Drawing Nos. ES-004, ES-007, ES-205, ES-410, and ES-601 noted Addendum 2 dated 02/24/2026, accompanies this Addendum and supersedes the same numbered previously issued drawings.

END OF ADDENDUM

Brady M. Sherlock, P.E.
Director, Division of Design
Design & Construction

Feb 24, 2026 - 4:25pm
 \\cashlab\Projects\NYS Office of General Services\2242619.02 - Wendy CF Replace Perimeter\06_Drawings\Electrical\ES-002-007 Security Site Plan.dwg
 36x24 PLOT SHEET

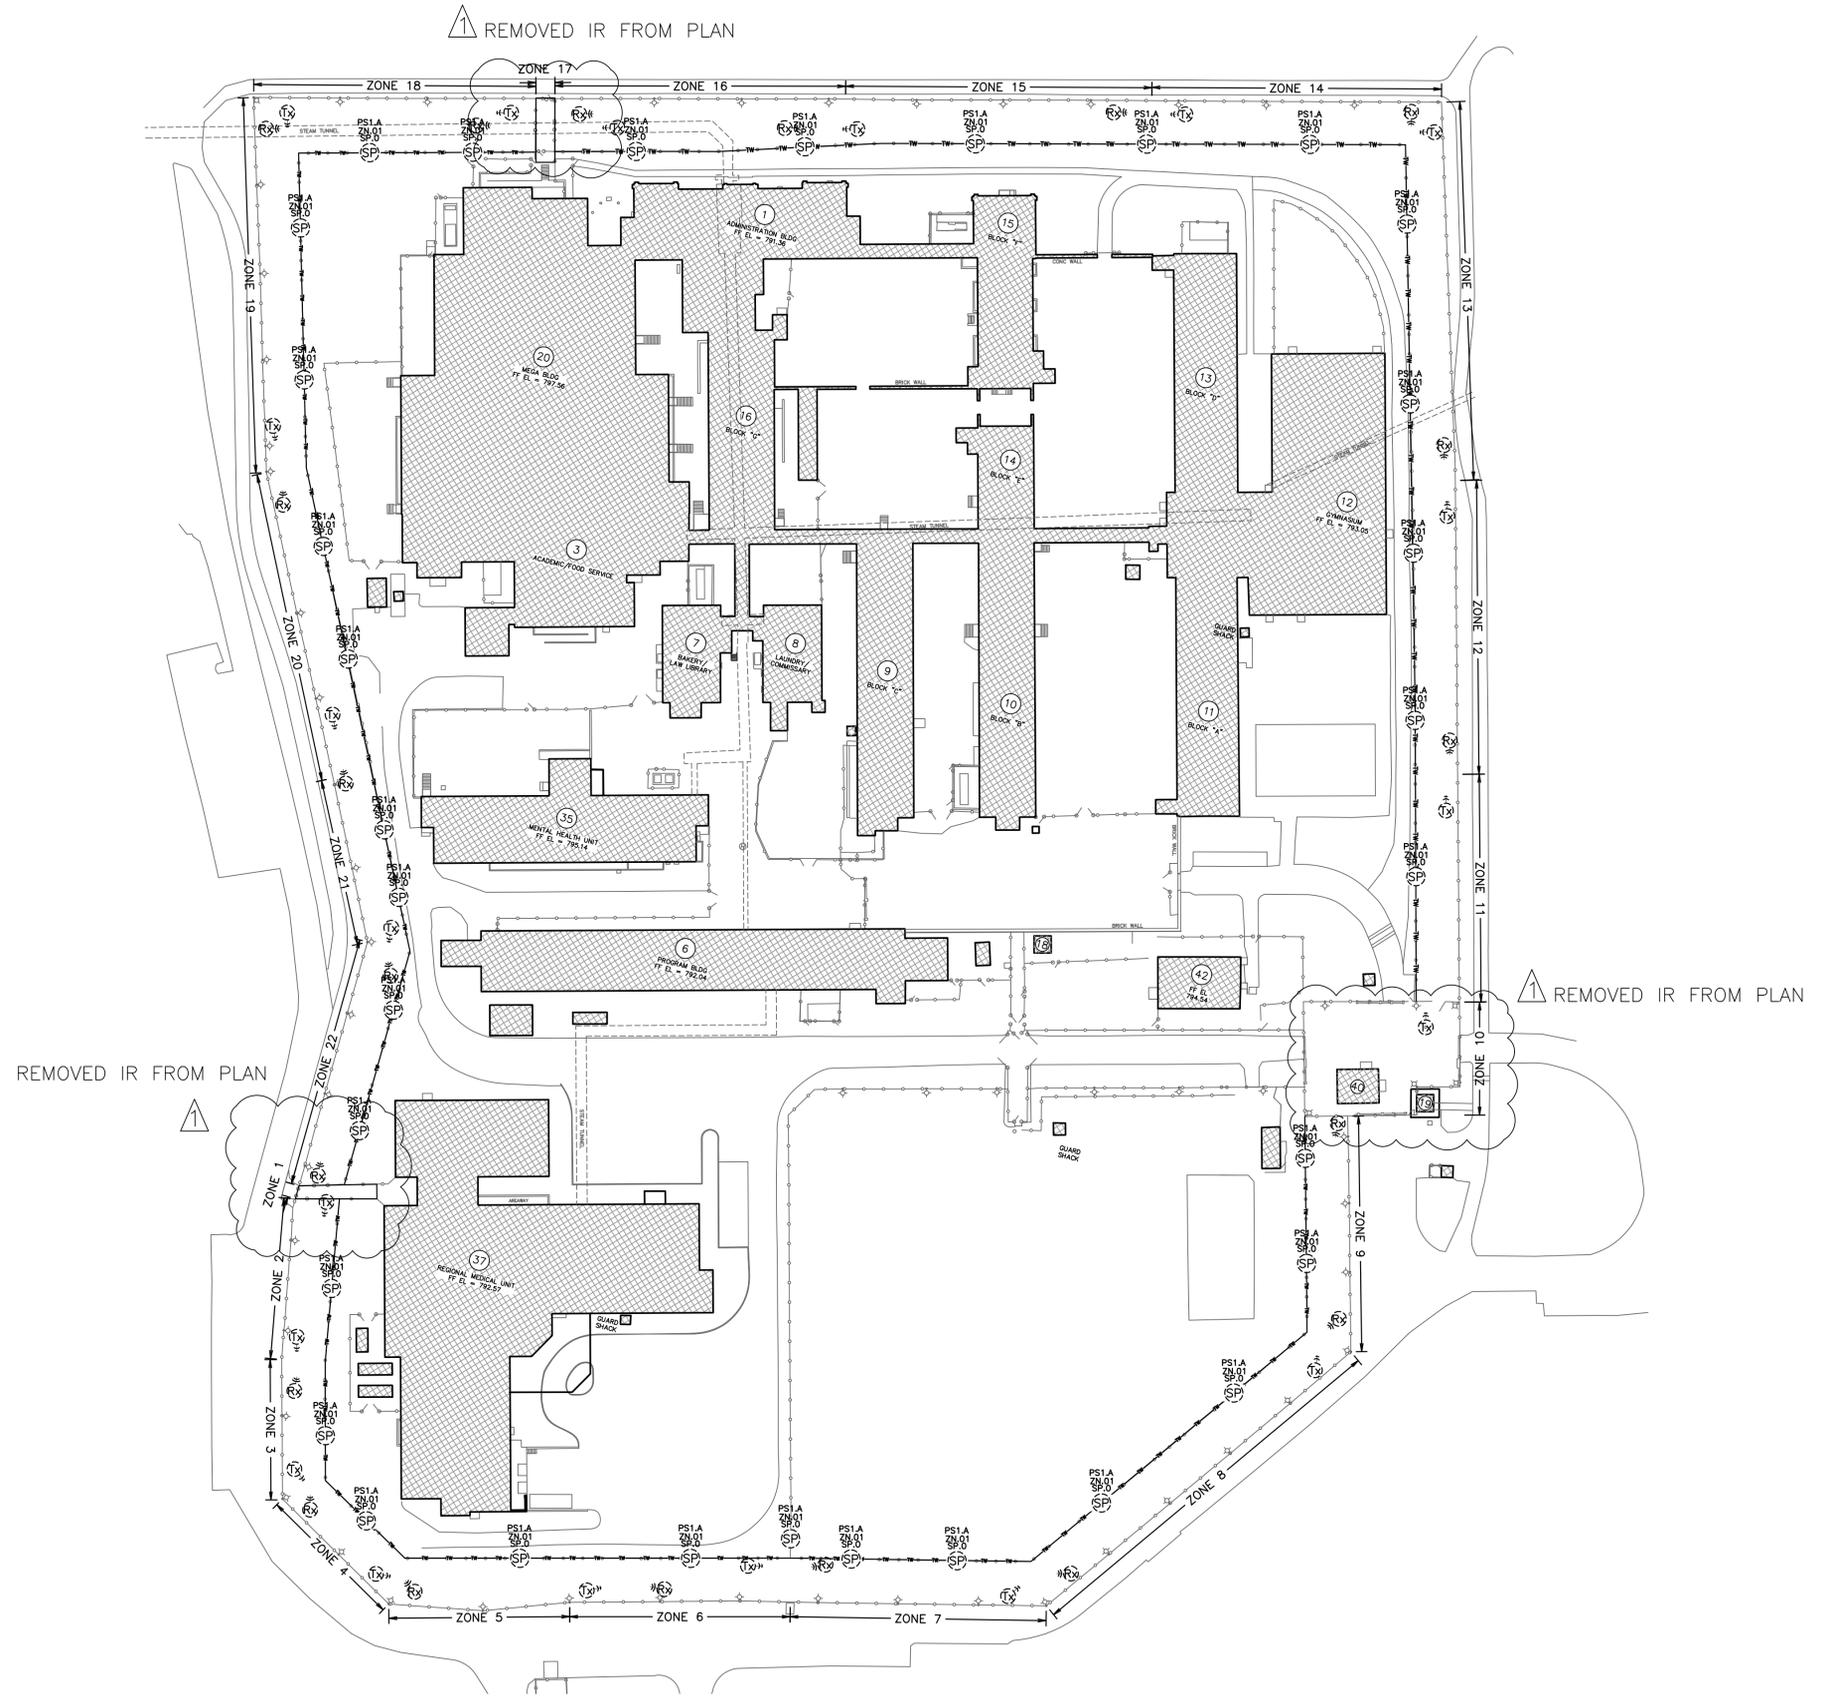

- ABBREVIATIONS
- FAS = FENCE ACCESSORY STATION
 - N = ENCLOSURE ID NUMBER
 - FAS ENCLOSURE NUMBER
 - C = CAMERA
 - 14 = CAMERA ID NUMBER
 - C.14 = EXISTING CAMERA POLE
 - CAMERA VIEW
 - CAMERA
 - = EXISTING SYSTEM CABLING AND RACEWAY SYSTEM
 - = EXISTING FENCE-MOUNTED SHAKER CABLE
 - Ⓢ = EXISTING SECURITY MANHOLE

- REMOVAL KEYED NOTES:
- 1 DISCONNECT AND REMOVE EXISTING MICROWAVE DETECTION SYSTEM, POSTS, BASES AND CABLING ONCE NEW SYSTEM IS INSTALLED AND OPERATIONAL.
 - 2 DISCONNECT AND REMOVE EXISTING INFRARED DETECTION SYSTEM, BASES AND CABLING ONCE MICROWAVE ZONE IS INSTALLED AND OPERATIONAL.

- GENERAL REMOVAL NOTES:
1. DISCONNECT AND REMOVE EXISTING SHAKER CABLE SYSTEM AFTER ASC1 & ASC2 ARE INSTALLED AND OPERATIONAL.
 2. DISCONNECT AND REMOVE ALL EXISTING COAX, FIBER AND PERIMETER DETECTION COMMUNICATION (MULTIPLEX) CABLING BACK TO IT'S SOURCE. MAINTAIN FAS ENCLOSURES FOR USE WITH REPLACEMENT SYSTEMS.
 3. DISCONNECT AND REMOVE ALL EXISTING PERIMETER CCTV CAMERAS INDICATED. REMOVE ASSOCIATED CABLING, CONTROLLERS, MEDIA CONVERTERS, POWER SUPPLIES, AND CABLING. MAINTAIN RACEWAY, POLES, ARMS AND BASES FOR NEW CCTV CAMERAS.

1 PERIMETER INTRUSION DETECTION REMOVAL SITE PLAN
 ES-007 SCALE: 1" = 60'-0"



WARNING:
 IT IS A VIOLATION OF NEW YORK EDUCATION LAW ART. 145 SEC. 7209 & ART. 147 SEC. 7307, FOR ANY PERSON, UNLESS ACTING UNDER THE DIRECTION OF A LICENSED ARCHITECT, PROFESSIONAL ENGINEER, OR LAND SURVEYOR, TO ALTER AN ITEM IN ANY WAY, IF AN ITEM BEARING THE SEAL OF AN ARCHITECT, ENGINEER, OR LAND SURVEYOR IS ALTERED; THE ALTERING ARCHITECT, ENGINEER, OR LAND SURVEYOR SHALL AFFIX TO THE ITEM THEIR SEAL AND NOTATION "ALTERED BY" FOLLOWED BY THEIR SIGNATURE AND DATE OF SUCH ALTERATION, AND A SPECIFIC DESCRIPTION OF THE ALTERATION.



EXP: 06/30/2027
 CERTIFICATE OF AUTHORIZATION NUMBER:
 PROFESSIONAL ENGINEERING: 0021272

CONTRACT: **ELECTRICAL**

TITLE: **REPLACE PERIMETER DETECTION & CAMERA SYSTEMS**

LOCATION: **WENDE CORRECTIONAL FACILITY
 3040 WENDE ROAD
 ALDEN, NEW YORK**

CLIENT: **DEPARTMENT OF CORRECTIONS
 AND COMMUNITY SUPERVISION**

| MARK | DATE | DESCRIPTION |
|-----------------|------------|-----------------|
| △ | 02/24/2026 | ADDENDUM 2 |
| | 01/09/2026 | BID DOCUMENT |
| PROJECT NUMBER: | | Q1910 -E |
| DESIGNED BY: | | MJP |
| DRAWN BY: | | MJP |
| FIELD CHECK: | | |
| APPROVED: | | |

SHEET TITLE:
**OVERALL PERIMETER
 INTRUSION DETECTION
 REMOVAL SITE PLAN**

DRAWING NUMBER:
ES-007

 

CONSULTANT



KEYED NOTES

1 REFER TO DRAWING ES-403 & ES-801 FOR PERIMETER PSMS, TWAIS, & CCTV VMS INTEGRATION DETAILS AND SCHEDULES.


2 PROVIDE 2RU EIA 19" RACK MOUNT DC POWER SUPPLY PART # CM362V-36V MANUFACTURED BY AAK POWER SUPPLY CORP. POWER SUPPLY TO INCLUDE 120VAC INPUT, 36VDC OUTPUT WITH OVER VOLTAGE PROTECTION. PROVIDE 2-12AWG THHN STRANDED POWER CABLE FROM ARSENAL TO EACH IR STACK VIA ASSOCIATED FAS ENCLOSURE AS REQUIRED.

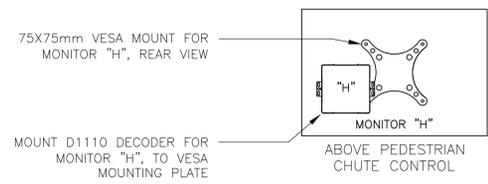

AXIS A9188 I/O BOARDS MOUNTED ON 6RU SWING PANELS ON BACK OF CONSOLES (TYPICAL OF 5)

75X75mm VESA MOUNT FOR ARTICULATING MONITORS, REAR VIEW (TYPICAL OF 9)

MONITOR DECODERS WITH LOCATION ID TAG (TYPICAL OF 12)

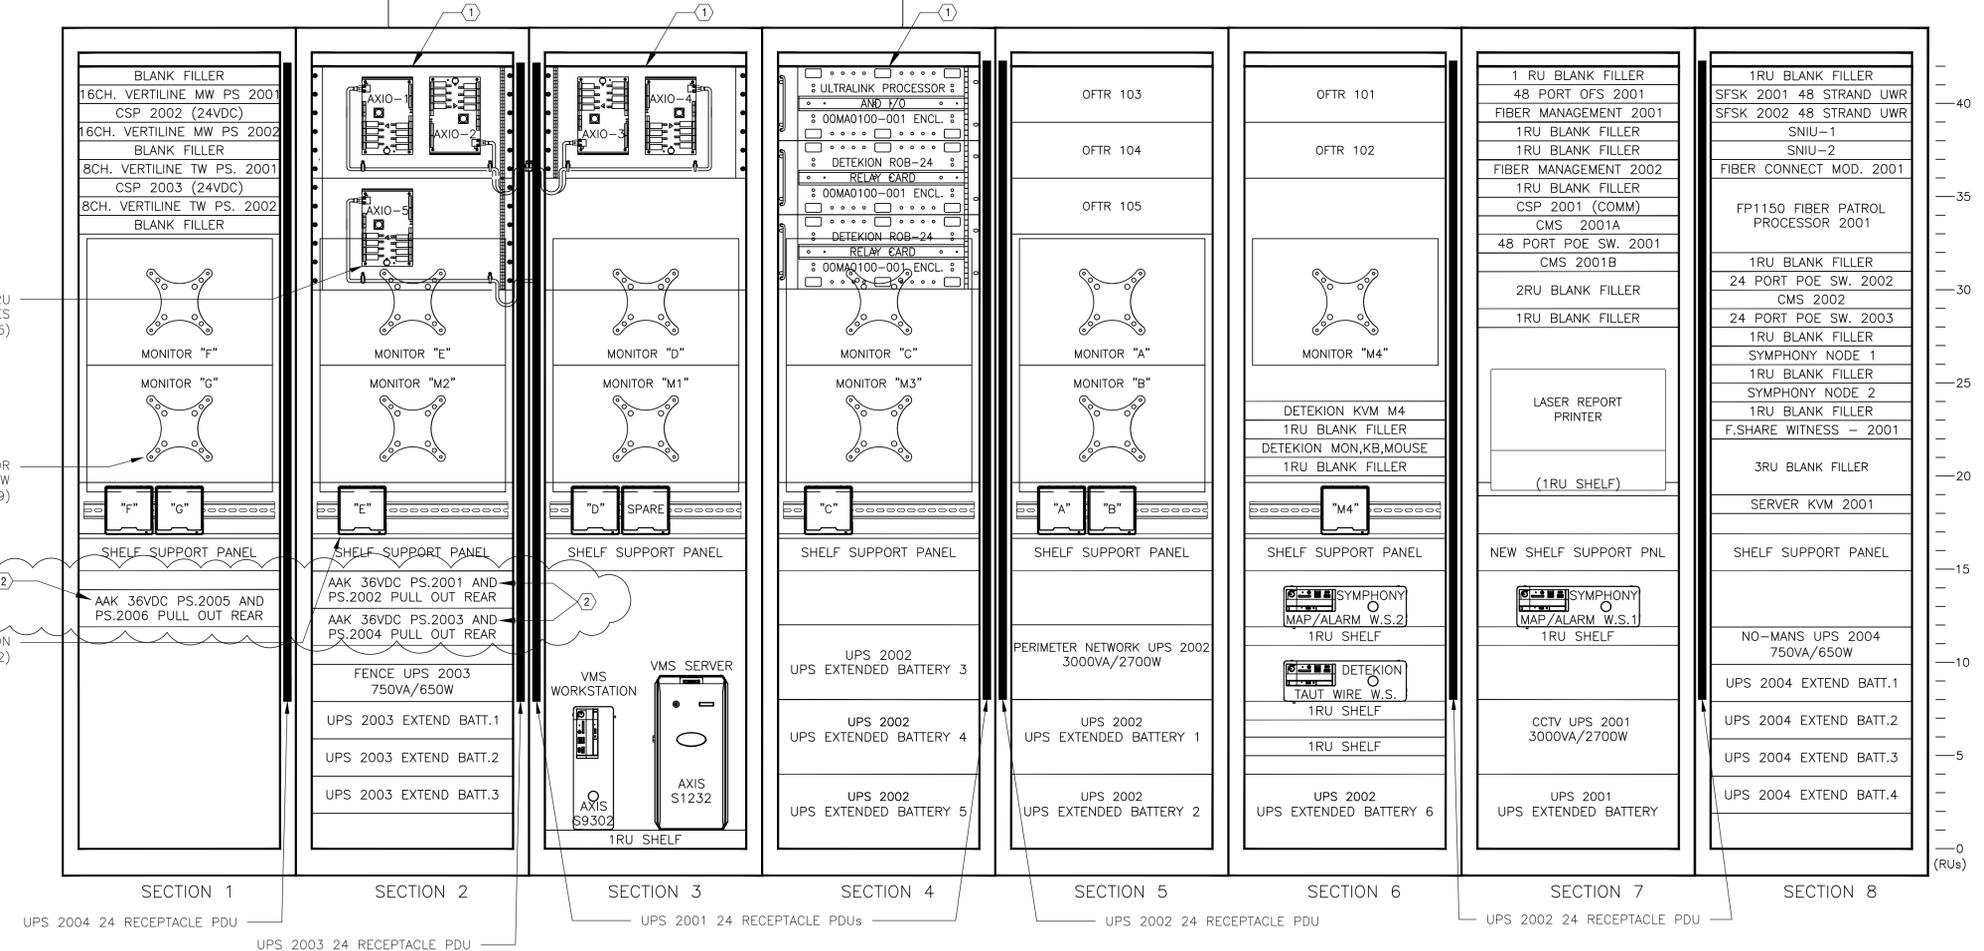

WARNING:

IT IS A VIOLATION OF NEW YORK EDUCATION LAW ART. 145 SEC. 7209 & ART. 147 SEC. 7307, FOR ANY PERSON, UNLESS ACTING UNDER THE DIRECTION OF A LICENSED ARCHITECT, PROFESSIONAL ENGINEER, OR LAND SURVEYOR, TO ALTER AN ITEM IN ANY WAY. IF AN ITEM BEARING THE SEAL OF AN ARCHITECT, ENGINEER, OR LAND SURVEYOR IS ALTERED, THE ALTERING ARCHITECT, ENGINEER, OR LAND SURVEYOR SHALL AFFIX TO THE ITEM THEIR SEAL AND NOTATION "ALTERED BY" FOLLOWED BY THEIR SIGNATURE AND DATE OF SUCH ALTERATION, AND A SPECIFIC DESCRIPTION OF THE ALTERATION.

EXP: 06/30/2027

CERTIFICATE OF AUTHORIZATION NUMBER:
PROFESSIONAL ENGINEERING: 0021272

CONTRACT: ELECTRICAL

TITLE: REPLACE PERIMETER DETECTION & CAMERA SYSTEMS

LOCATION: WENDE CORRECTIONAL FACILITY
3040 WENDE ROAD
ALDEN, NEW YORK

CLIENT: DEPARTMENT OF CORRECTIONS AND COMMUNITY SUPERVISION

| MARK | DATE | DESCRIPTION |
|--------------------------|------------|--------------|
| △ | 02/24/2026 | ADDENDUM 2 |
| | 01/09/2026 | BID DOCUMENT |
| PROJECT NUMBER: Q1910 -E | | |
| DESIGNED BY: | MJP | |
| DRAWN BY: | MJP | |
| FIELD CHECK: | | |
| APPROVED: | | |

SHEET TITLE:

ARSENAL PERIMETER SECURITY CONSOLE REAR ELEVATION

DRAWING NUMBER: ES-205

1 ARSENAL CONSOLE LAYOUT - REAR
ES-205 SCALE: NTS



WARNING:
IT IS A VIOLATION OF NEW YORK EDUCATION LAW ART. 145 SEC. 7209 & ART. 147 SEC. 7307, FOR ANY PERSON, UNLESS ACTING UNDER THE DIRECTION OF A LICENSED ARCHITECT, PROFESSIONAL ENGINEER, OR LAND SURVEYOR, TO ALTER AN ITEM IN ANY WAY, IF AN ITEM BEARING THE SEAL OF AN ARCHITECT, ENGINEER, OR LAND SURVEYOR IS ALTERED; THE ALTERING ARCHITECT, ENGINEER, OR LAND SURVEYOR SHALL AFFIX TO THE ITEM THEIR SEAL AND NOTATION "ALTERED BY" FOLLOWED BY THEIR SIGNATURE AND DATE OF SUCH ALTERATION, AND A SPECIFIC DESCRIPTION OF THE ALTERATION.



EXP: 06/30/2027

CERTIFICATE OF AUTHORIZATION NUMBER:
PROFESSIONAL ENGINEERING: 0021272


CONTRACT:
ELECTRICAL

TITLE:
REPLACE PERIMETER DETECTION & CAMERA SYSTEMS

LOCATION:
WENDE CORRECTIONAL FACILITY
3040 WENDE ROAD
ALDEN, NEW YORK


CLIENT:
DEPARTMENT OF CORRECTIONS
AND COMMUNITY SUPERVISION

| | | |
|--|------------|--------------|
| MARK | DATE | DESCRIPTION |
| | 02/24/2026 | ADDENDUM 2 |
| | 01/09/2026 | BID DOCUMENT |
| PROJECT NUMBER: | Q1910 -E | |
| DESIGNED BY: | MJP | |
| DRAWN BY: | MJP | |
| FIELD CHECK: | | |
| APPROVED: | | |
| SHEET TITLE: | | |
| MICROWAVE AND IR-STACK COMMUNICATION AND POWER RISER DIAGRAM | | |
| DRAWING NUMBER: | | |
| ES-410 | | |

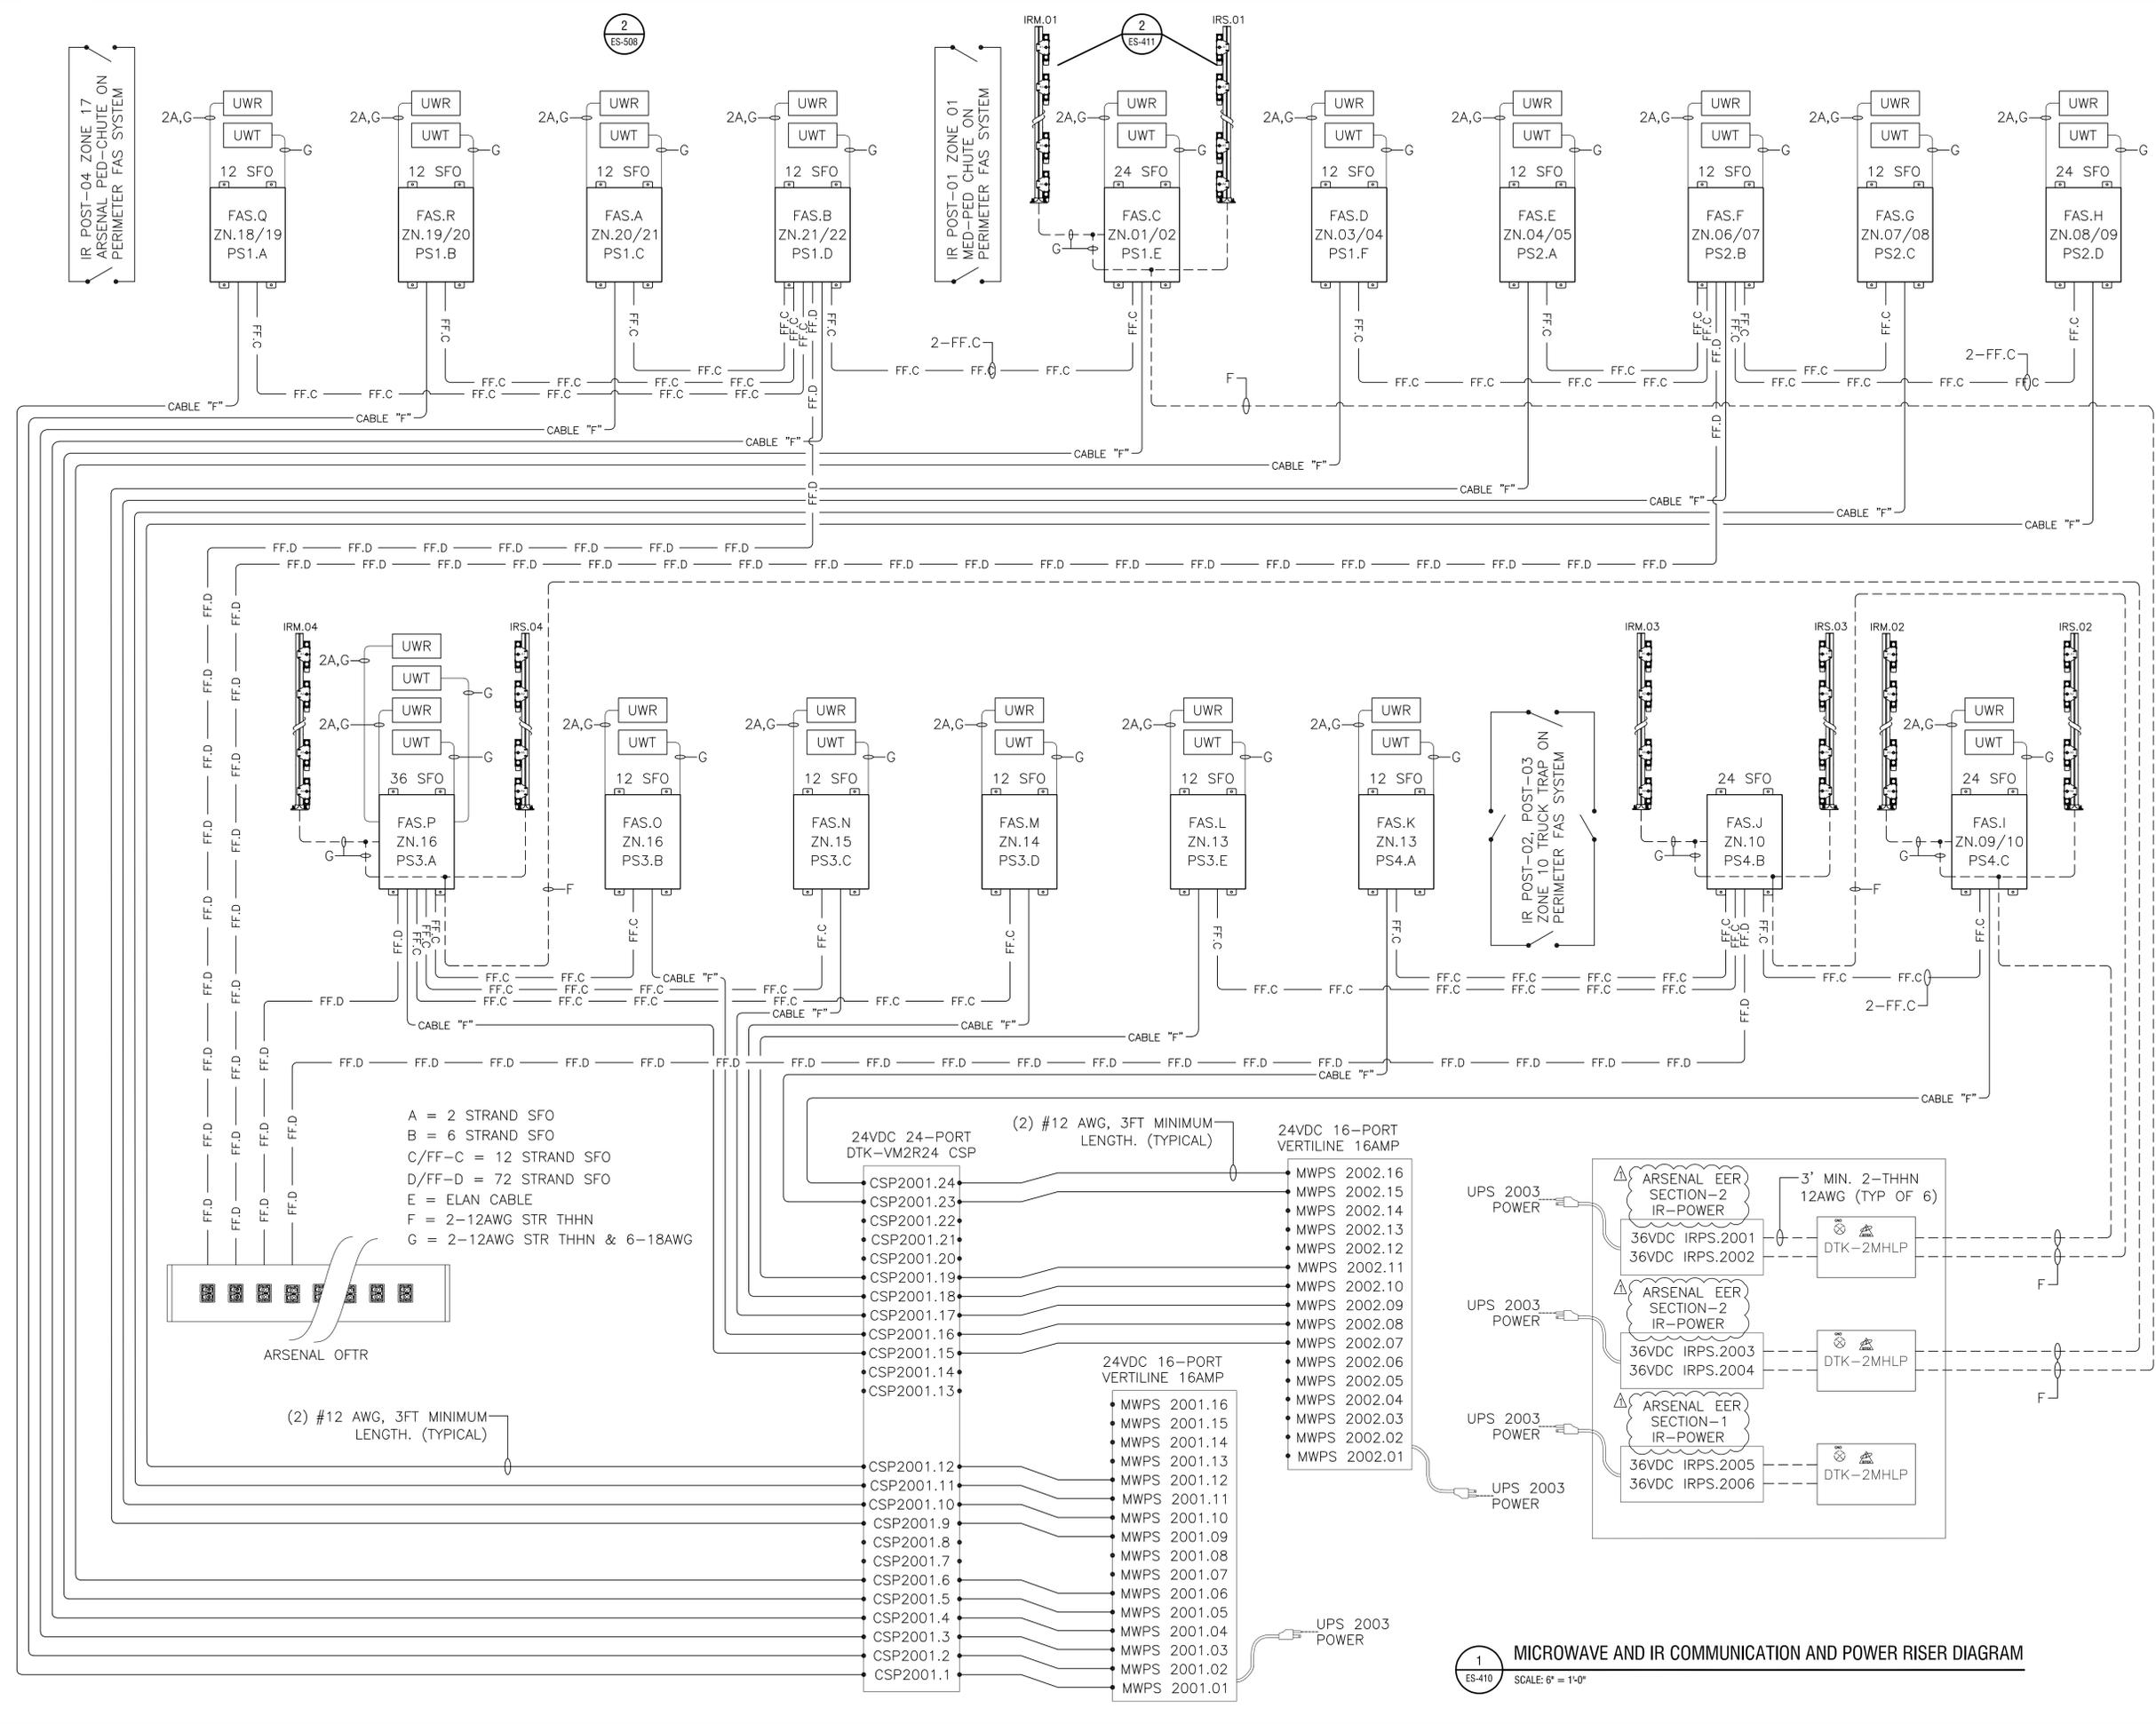


1 ES-410 SCALE: 6" = 1'-0"

Feb 24, 2026 - 12:47pm
 \\csh\lab\Projects\NYS Office of General Services\2242619.02 - Wendy CF Replace Perimeter\06_Drawings\Electrical\ES-601 Perimeter Camera Details.dwg
 36x24 PLOT SHEET

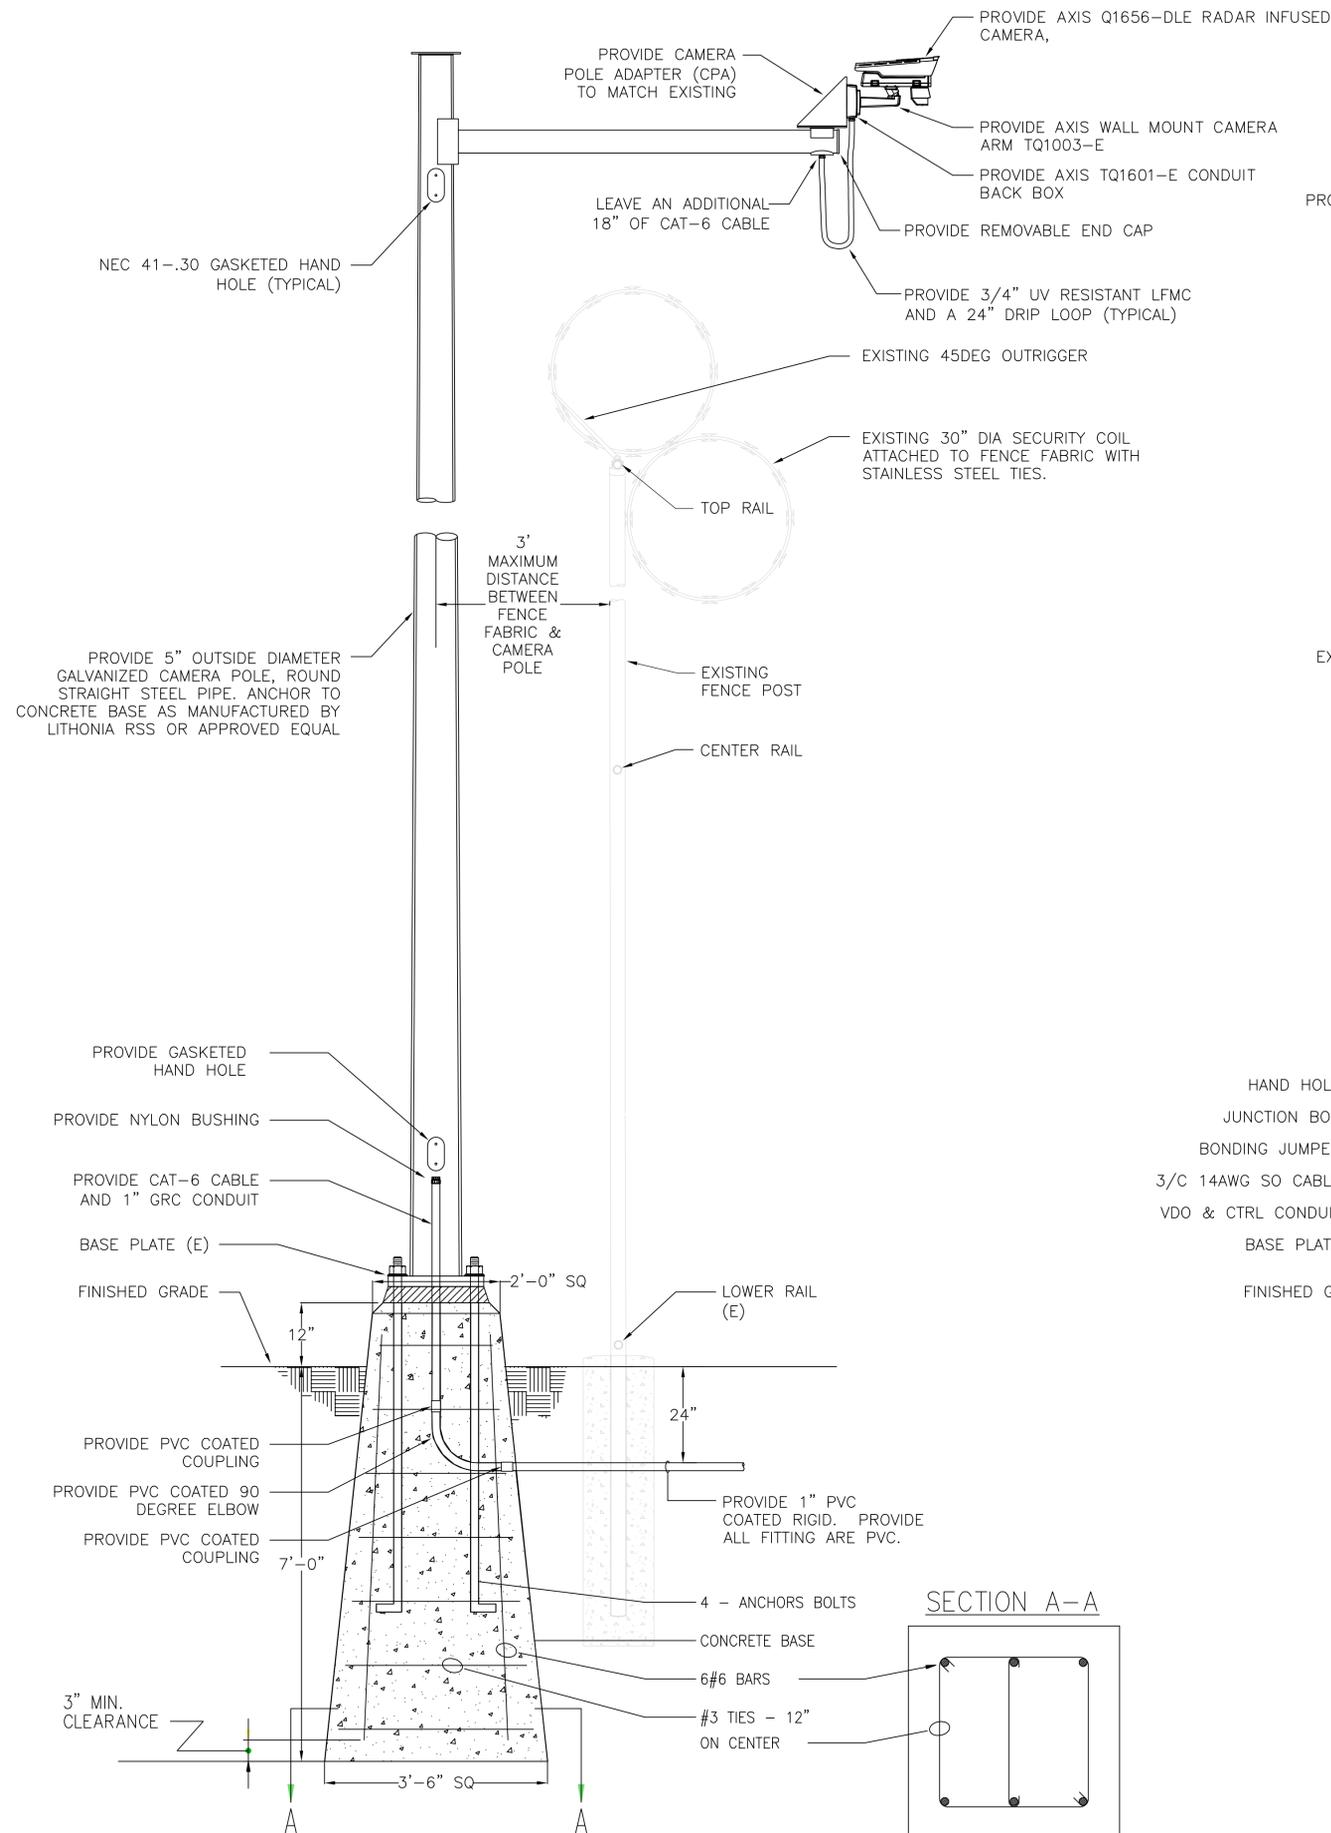

1 PERIMETER CAMERA, POLE & BASE DETAIL
 E-601 NTS: TYPICAL

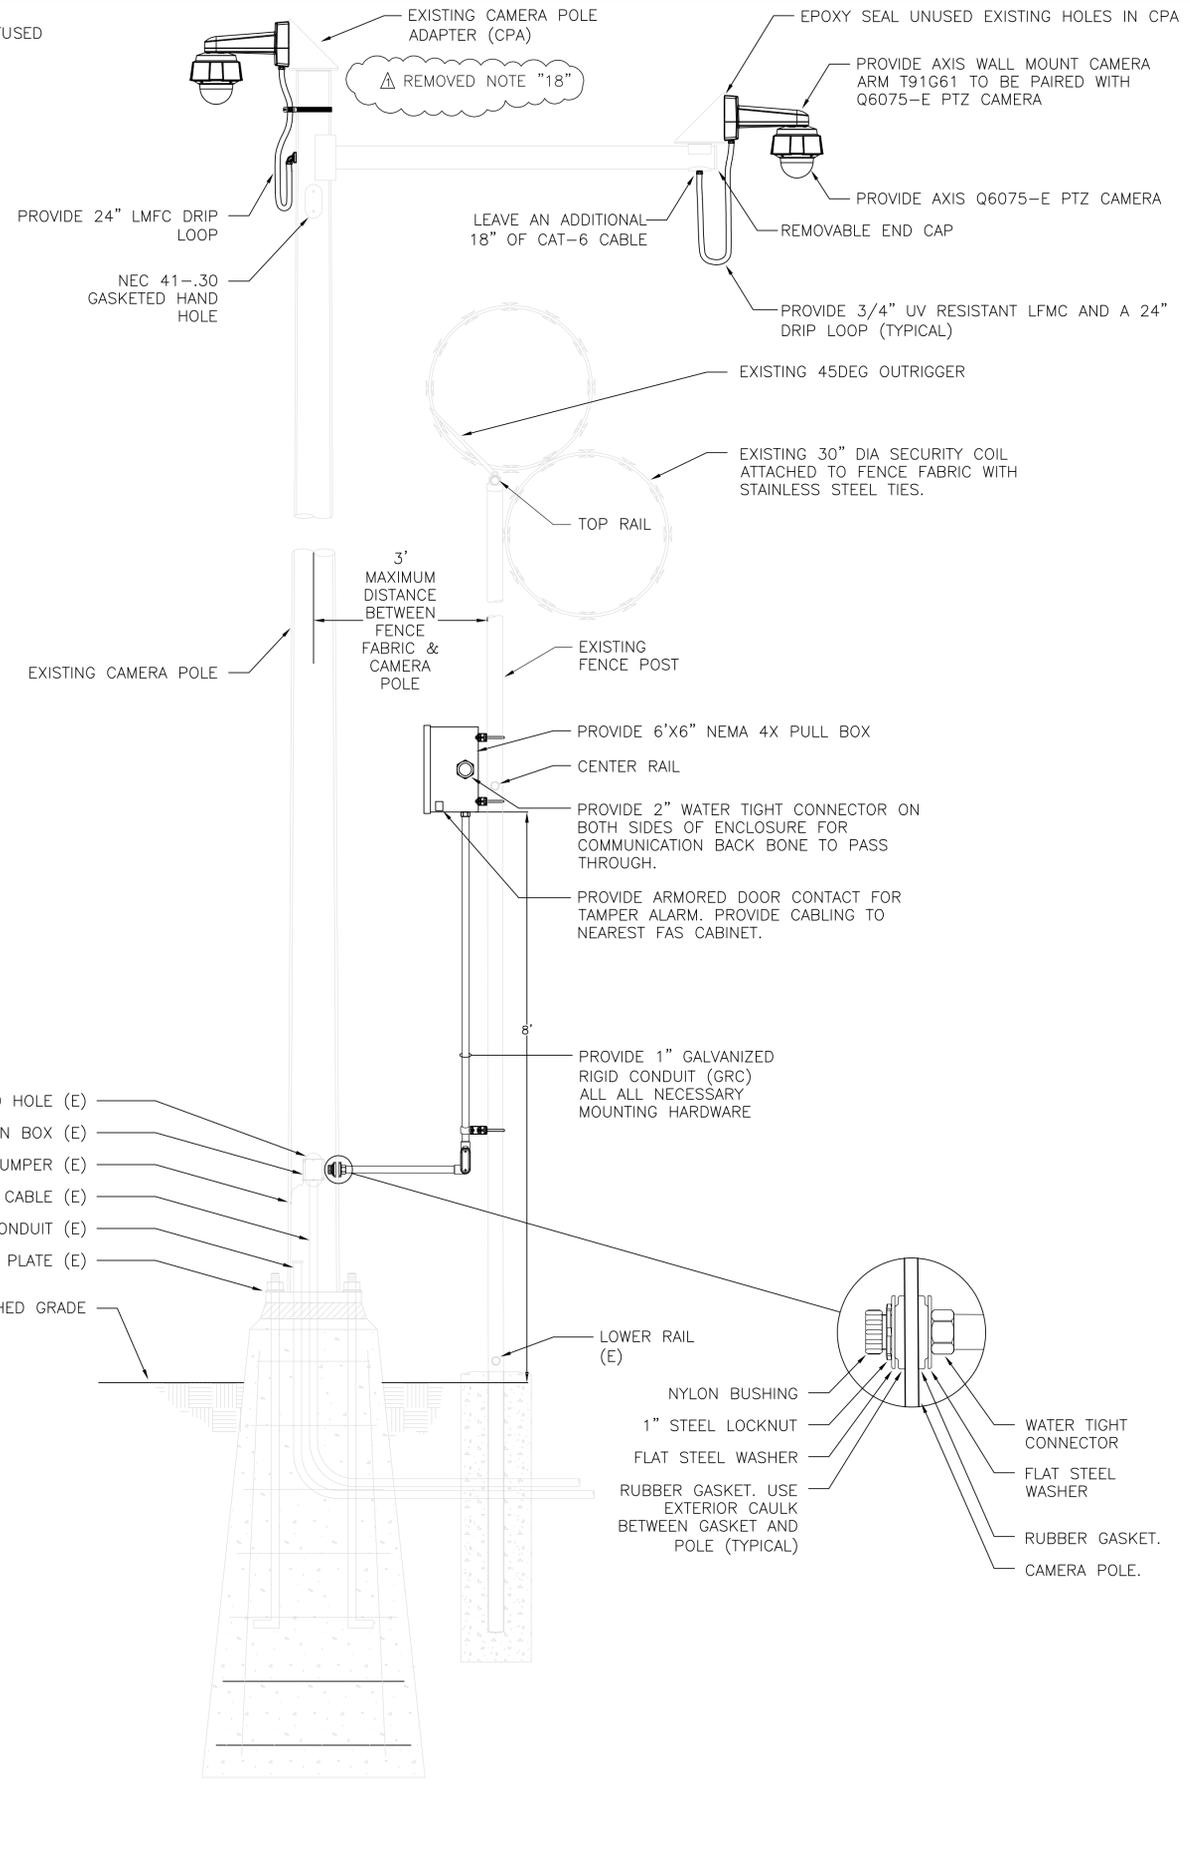

2 EXISTING PERIMETER CAMERA POLE - CAMERA INSTALLATION DETAIL
 E-601 NTS: TYPICAL

CONSULTANT

WARNING:
 IT IS A VIOLATION OF NEW YORK EDUCATION LAW ART. 145 SEC. 7209 & ART. 147 SEC. 7307, FOR ANY PERSON, UNLESS ACTING UNDER THE DIRECTION OF A LICENSED ARCHITECT, PROFESSIONAL ENGINEER, OR LAND SURVEYOR, TO ALTER AN ITEM IN ANY WAY. IF AN ITEM BEARING THE SEAL OF AN ARCHITECT, ENGINEER, OR LAND SURVEYOR IS ALTERED, THE ALTERING ARCHITECT, ENGINEER, OR LAND SURVEYOR SHALL AFFIX TO THE ITEM THEIR SEAL AND NOTATION "ALTERED BY" FOLLOWED BY THEIR SIGNATURE AND DATE OF SUCH ALTERATION, AND A SPECIFIC DESCRIPTION OF THE ALTERATION.



EXP: 06/30/2027

CERTIFICATE OF AUTHORIZATION NUMBER:
 PROFESSIONAL ENGINEERING: 0021272

CONTRACT: ELECTRICAL

TITLE: REPLACE PERIMETER DETECTION & CAMERA SYSTEMS

LOCATION: WENDE CORRECTIONAL FACILITY
 3040 WENDE ROAD
 ALDEN, NEW YORK

CLIENT: DEPARTMENT OF CORRECTIONS AND COMMUNITY SUPERVISION

| MARK | DATE | DESCRIPTION |
|-------------------------|------------|--------------|
| △ | 02/24/2026 | ADDENDUM 2 |
| | 01/09/2026 | BID DOCUMENT |
| PROJECT NUMBER: Q1910-E | | |
| DESIGNED BY: MJP | | |
| DRAWN BY: MJP | | |
| FIELD CHECK: | | |
| APPROVED: | | |

SHEET TITLE: PERIMETER CAMERA DETAILS

DRAWING NUMBER: ES-601